





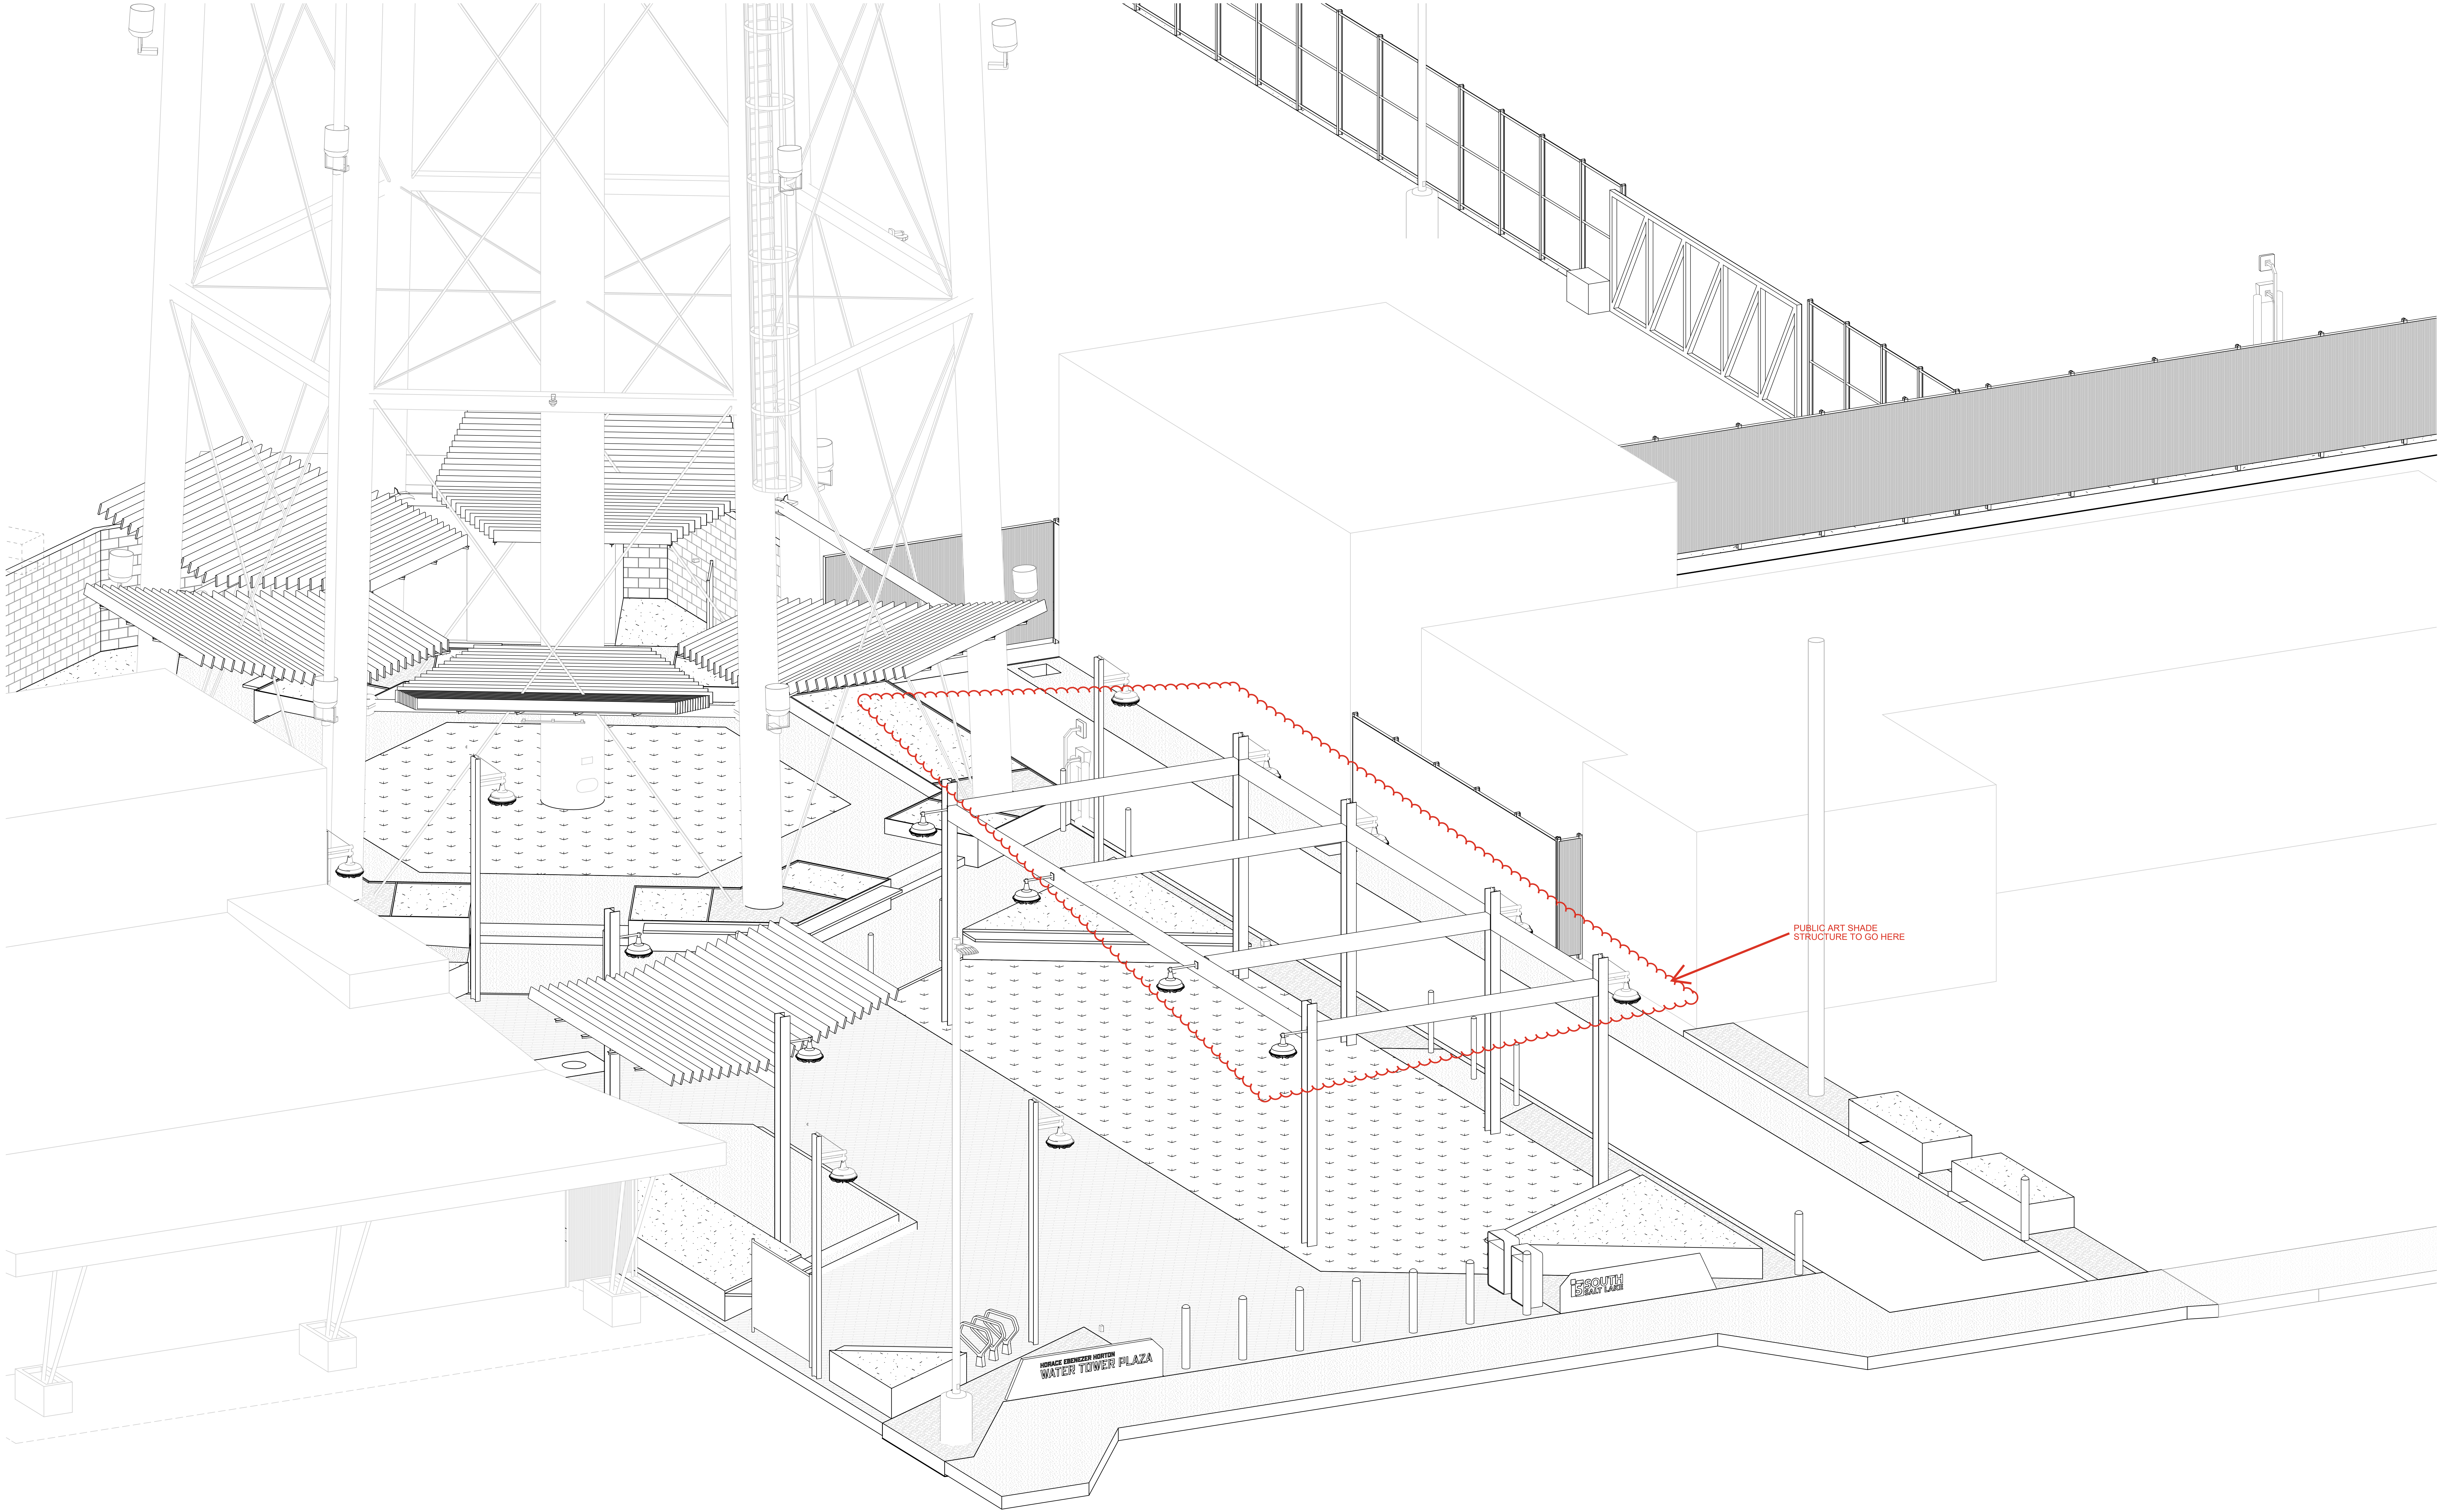

HORACE EBENEZER HORTON
WATER TOWER PLAZA

15 SOUTH
SALT LAKE

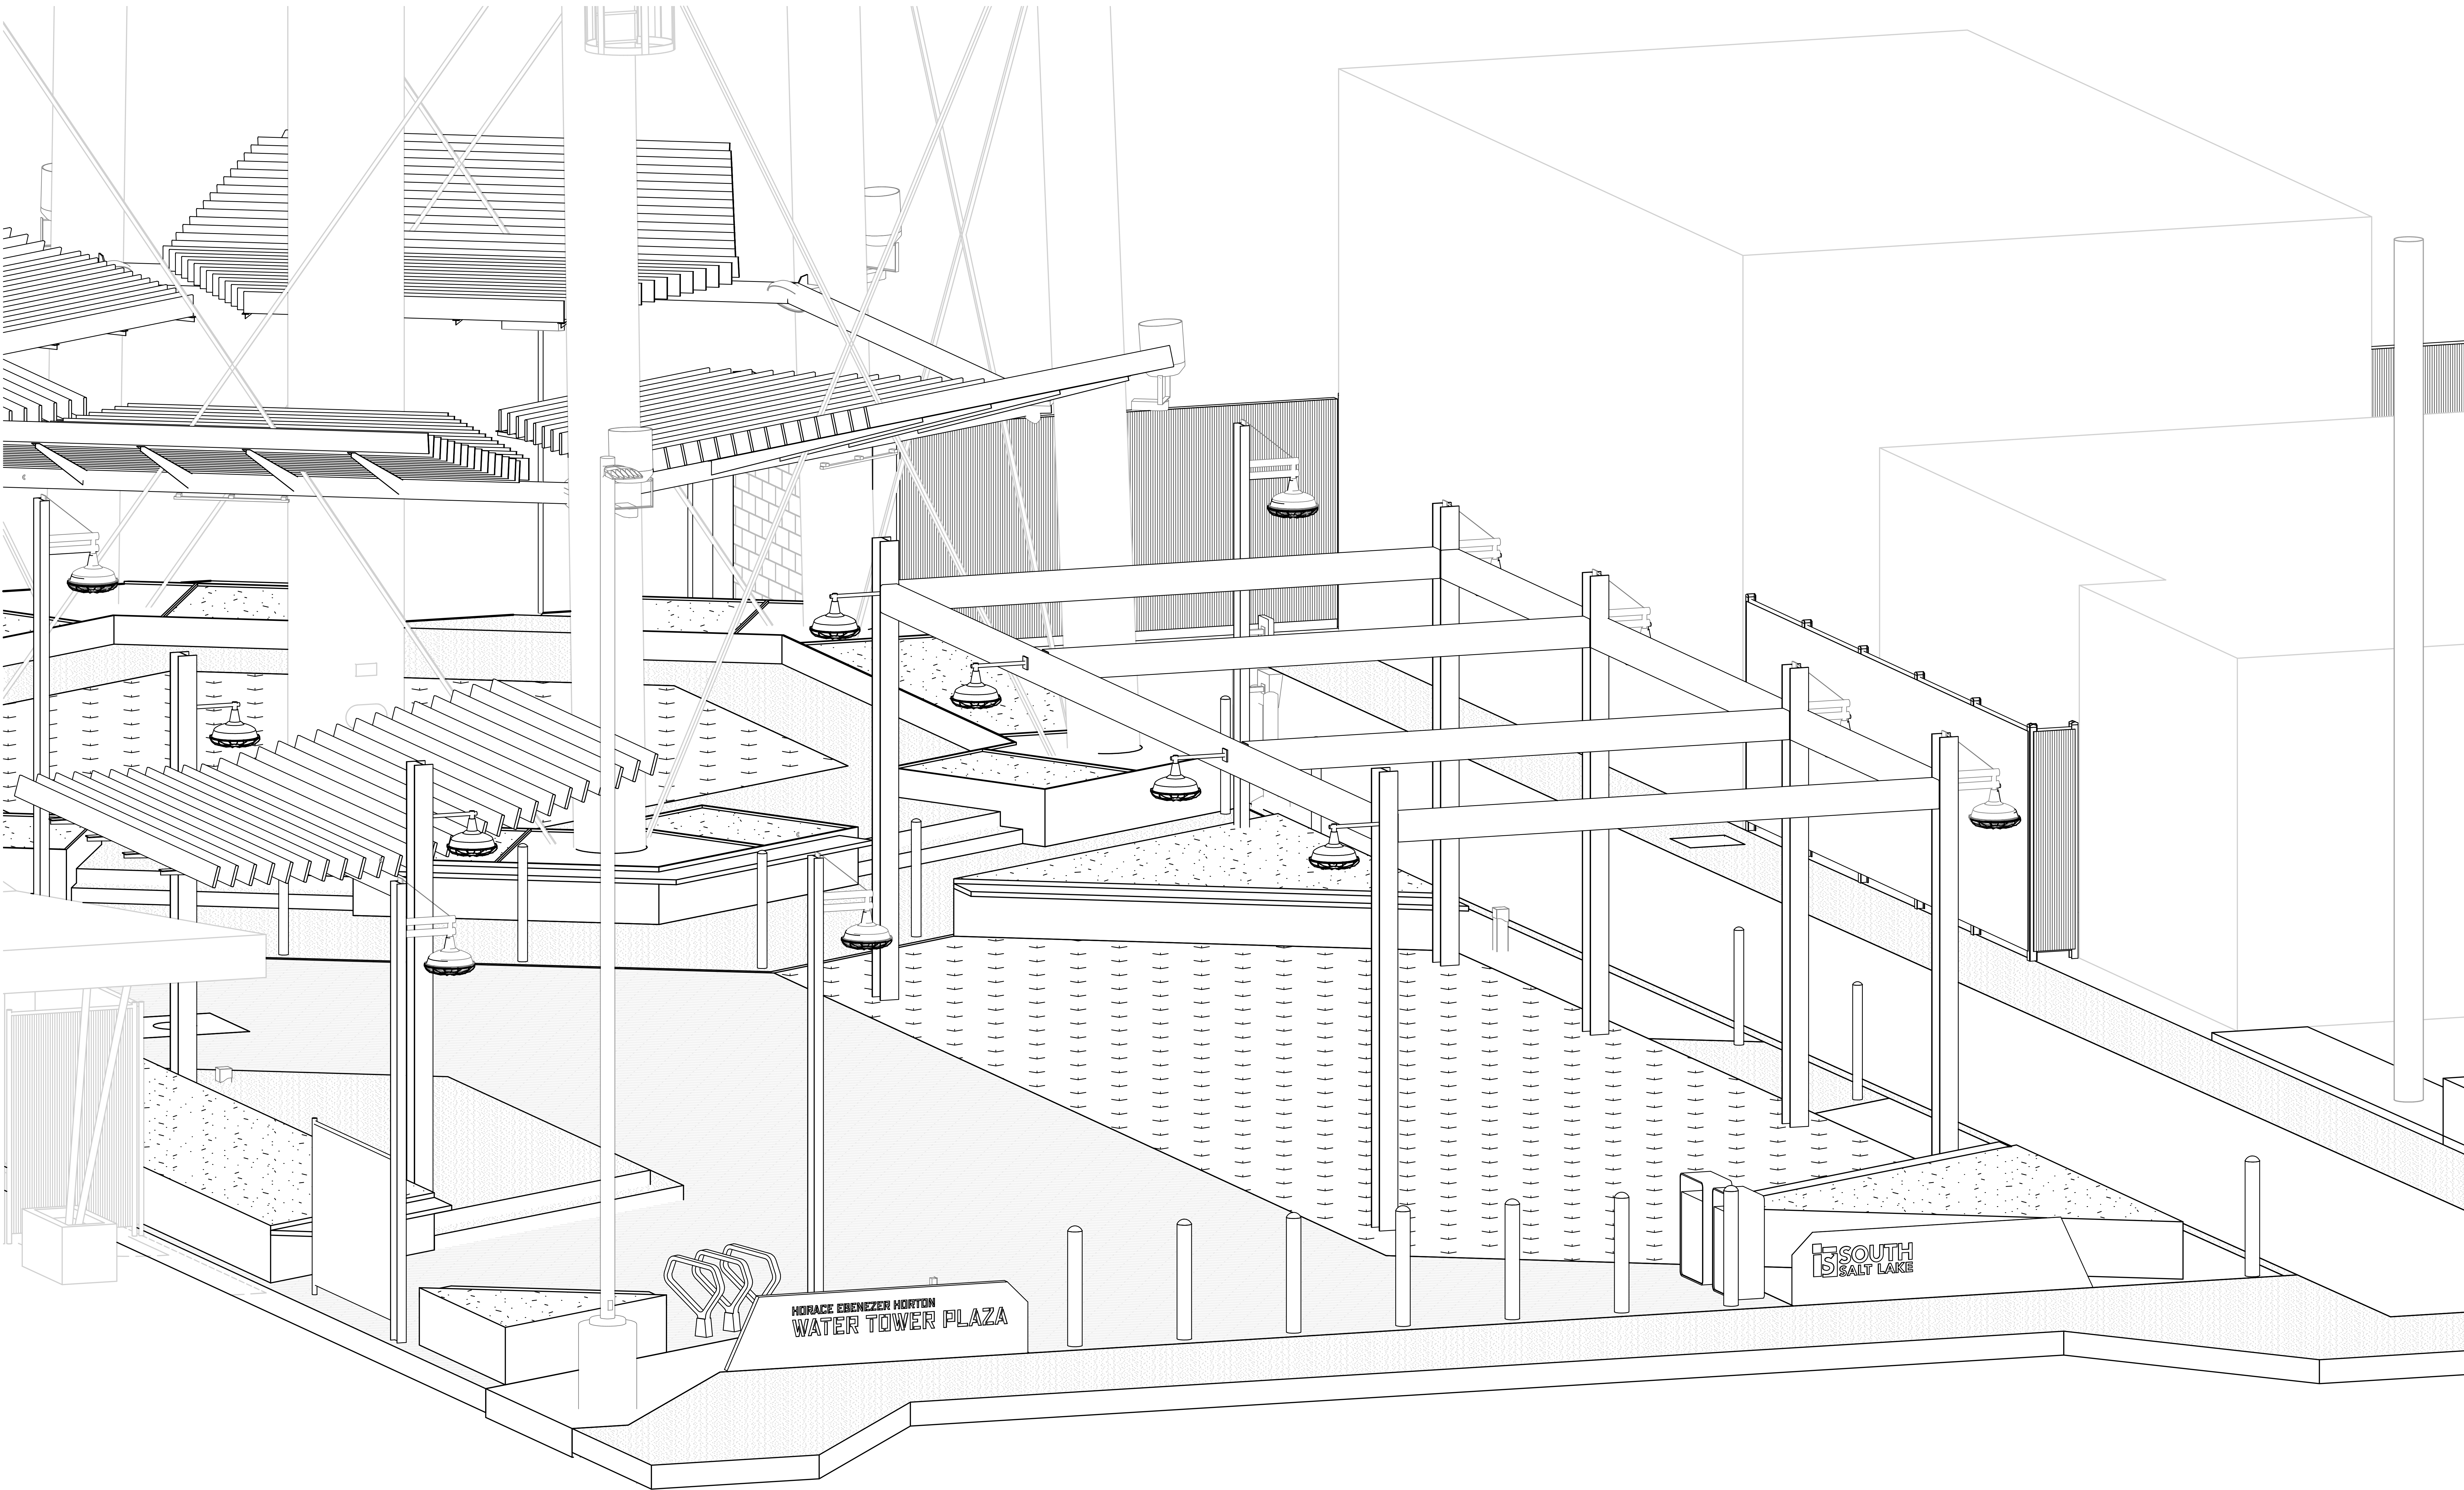

360 west aspen avenue
salt lake city, utah 84101
801 532 4422

UNLESS A PROFESSIONAL SEAL WITH SIGNATURE AND
DATE IS AFFIXED, THIS DOCUMENT IS PRELIMINARY AND IS
NOT INTENDED FOR CONSTRUCTION, RECORDING,
PURPOSES, OR IMPLEMENTATION


THE DESIGN SHOWN AND DESCRIBED HEREIN INCLUDING
ALL TECHNICAL DRAWINGS, GRAPHIC REPRESENTATIONS &
MODELS THEREOF, ARE PROPRIETARY & CAN NOT BE
COPIED, DULICATED, OR COMMERCIALLY EXPLOITED IN
WHOLE OR IN PART WITHOUT THE SOLE AND EXPRESS
WRITTEN PERMISSION FROM METHOD STUDIO INC.



project:
**South Salt
Lake Public
Works
Campus**

195 West Oakland Ave
South Salt Lake, Utah 84115

title:
SITE PLAN

sheet:
A001

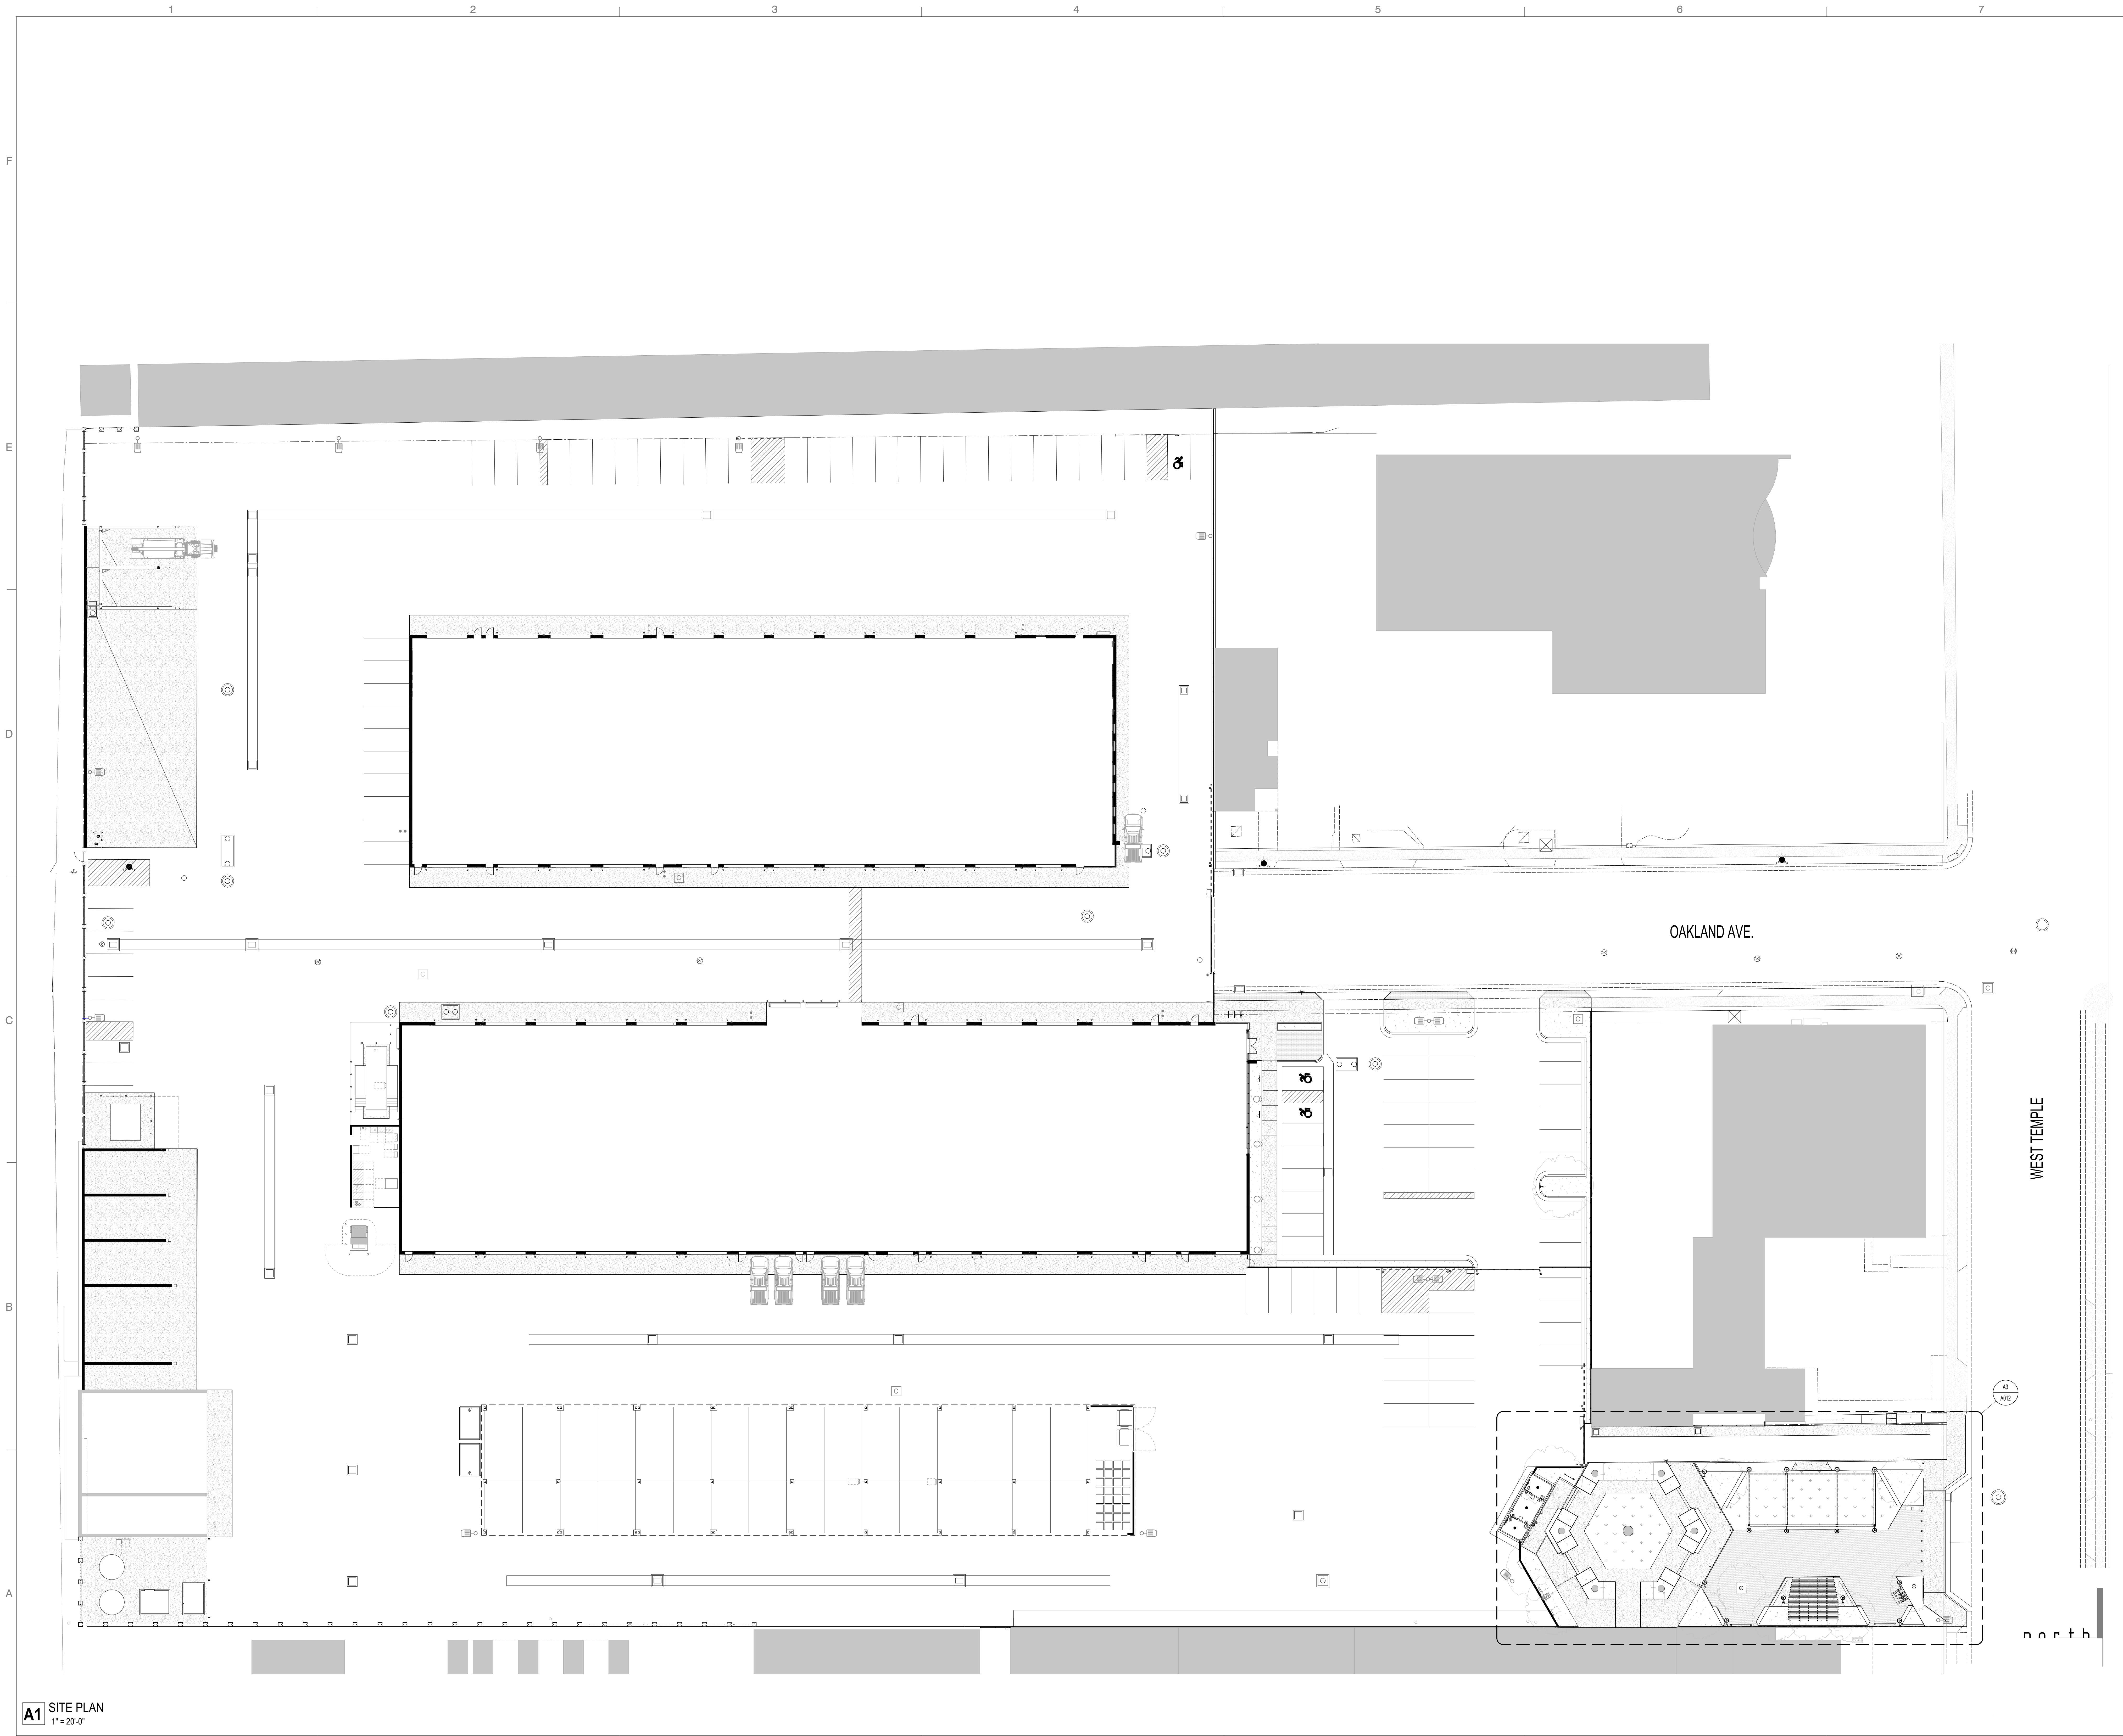

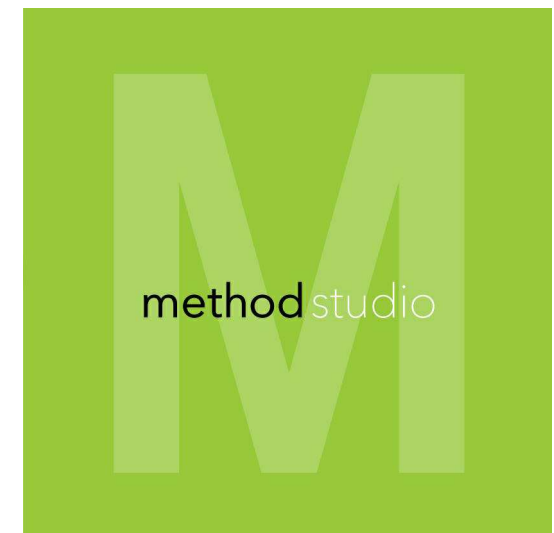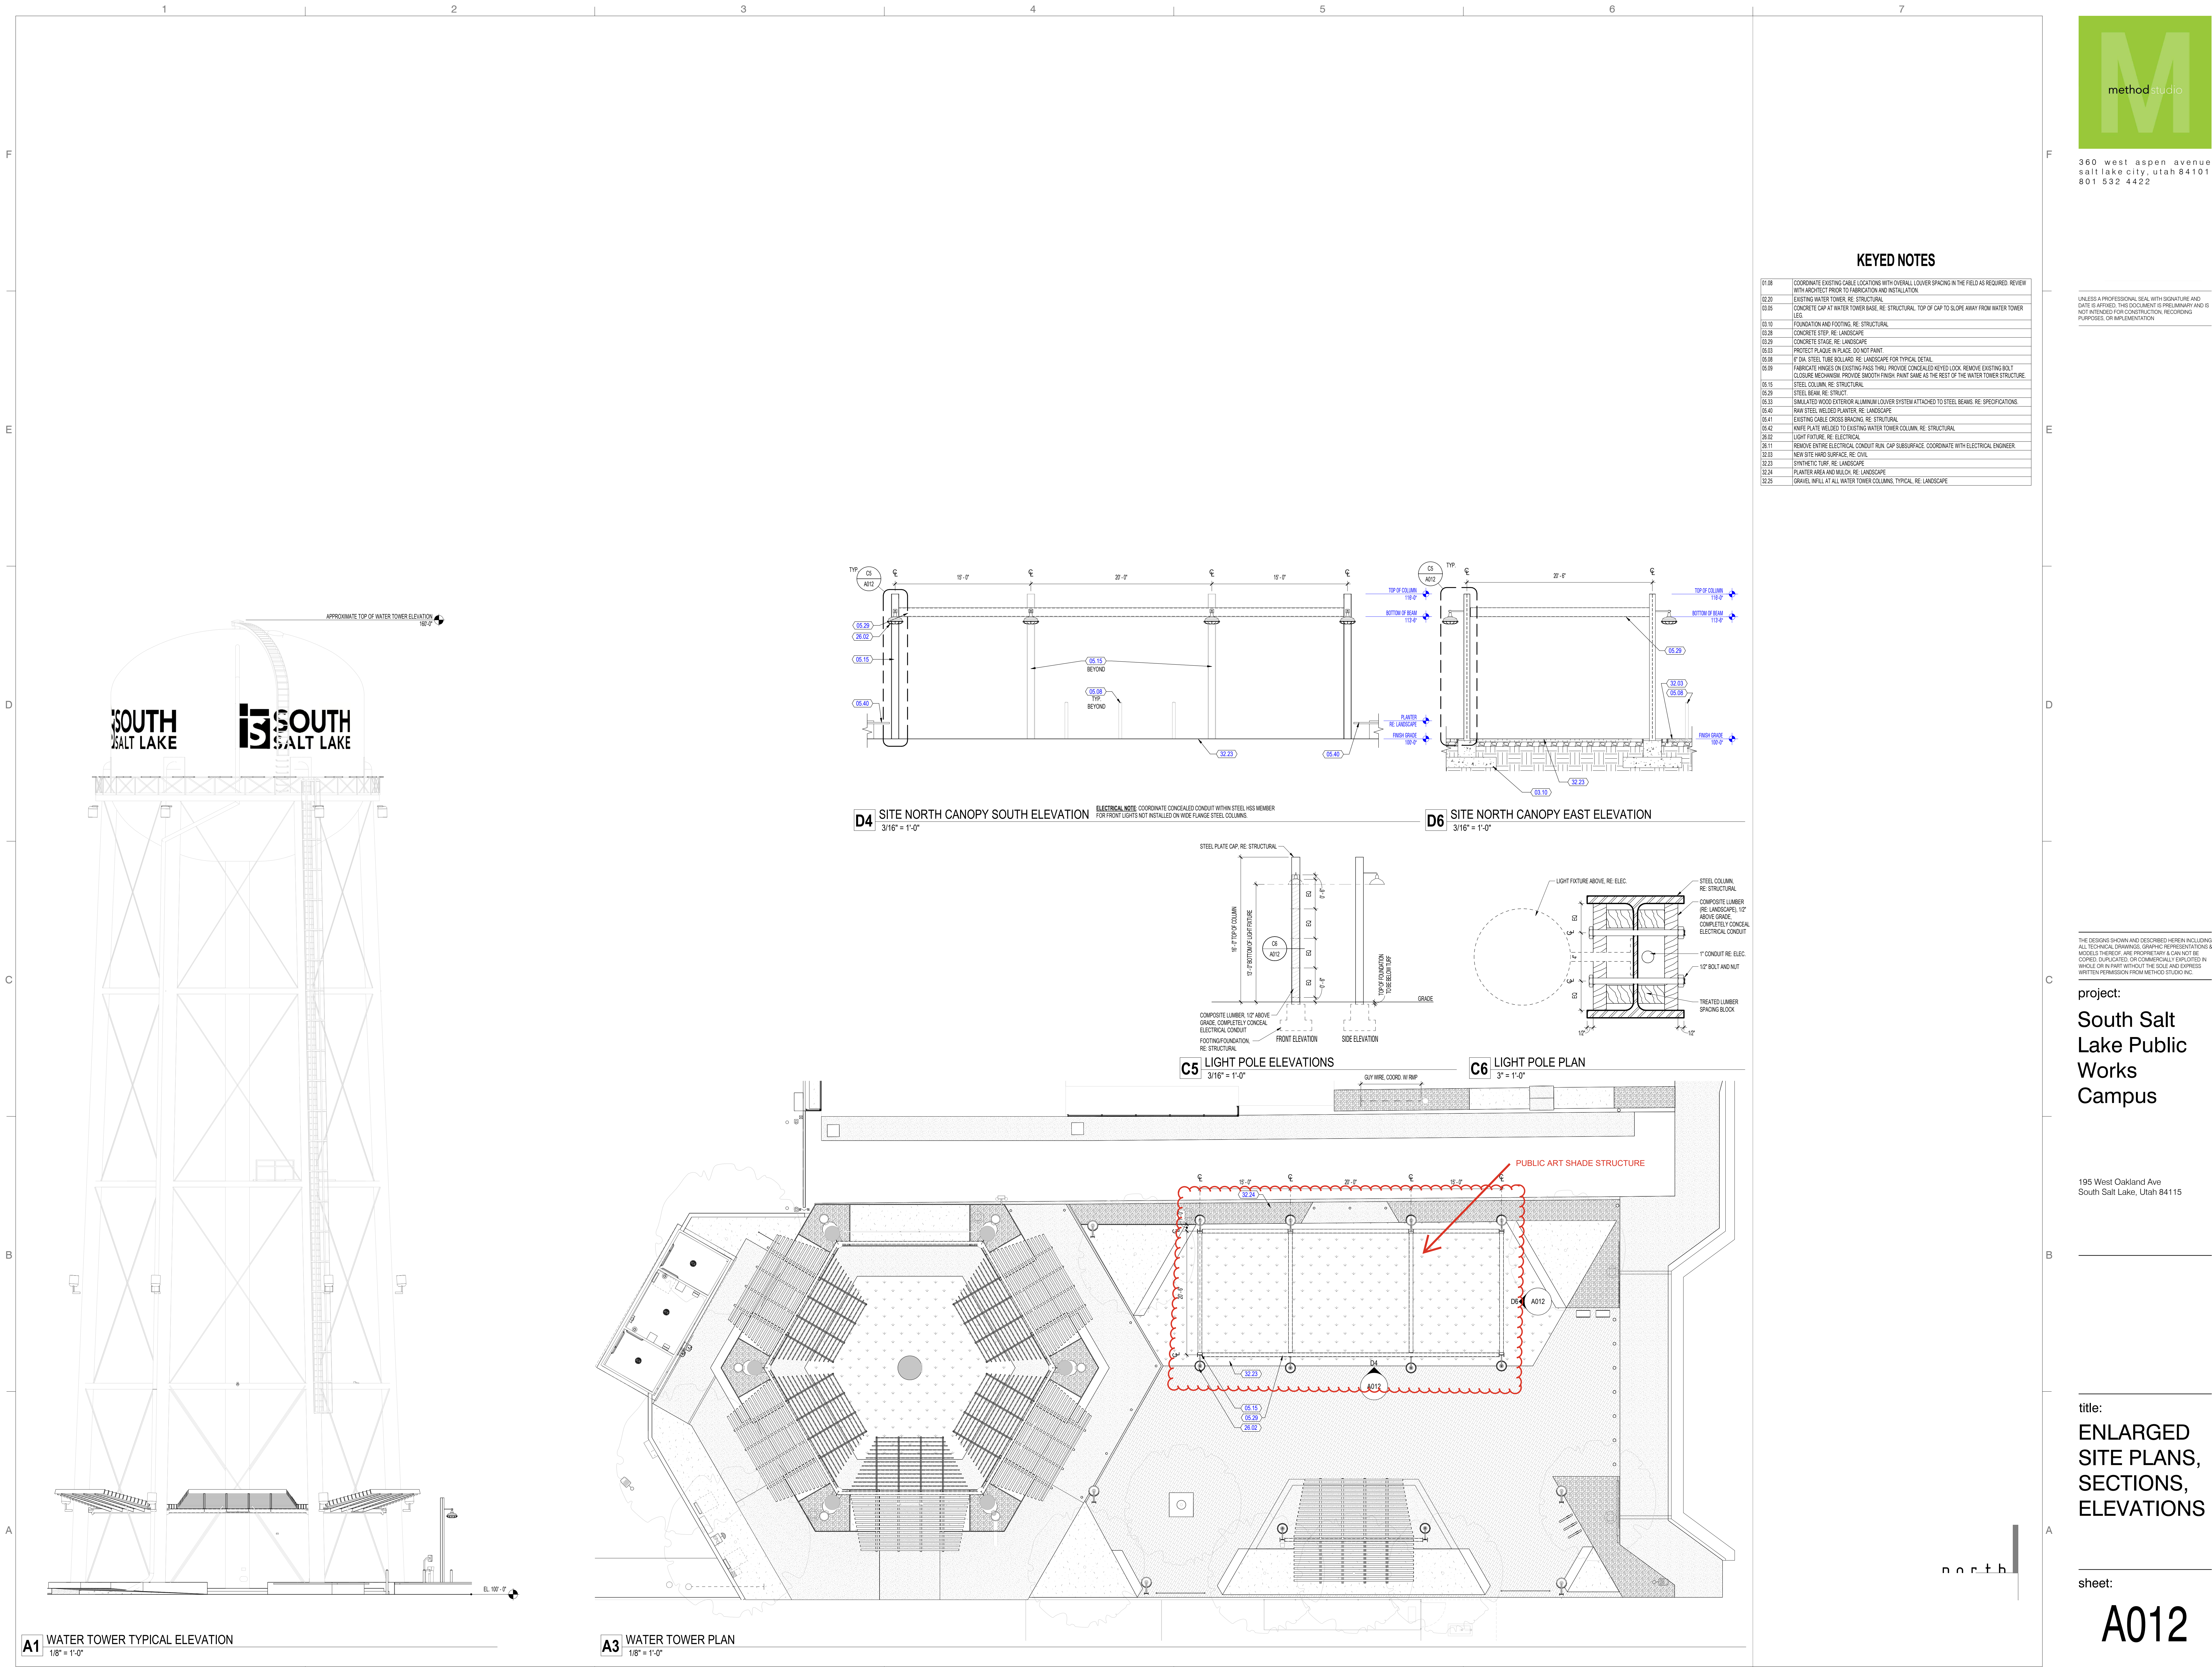

360 west aspen avenue
salt lake city, utah 84101
801 532 4422

UNLESS A PROFESSIONAL SEAL WITH SIGNATURE AND DATE IS AFFIXED, THIS DOCUMENT IS PRELIMINARY AND IS NOT INTENDED FOR CONSTRUCTION, RECORDING, PURPOSES, OR IMPLEMENTATION


THE DESIGN SHOWN AND DESCRIBED HEREIN INCLUDING ALL TECHNICAL DRAWINGS, GRAPHIC REPRESENTATIONS & MODELS THEREOF, ARE PROPRIETARY & CAN NOT BE COPIED, CLONED, LOANED, OR COMMERCIALLY EXPLOITED IN WHOLE OR IN PART WITHOUT THE SOLE AND EXPRESS WRITTEN PERMISSION FROM METHOD STUDIO, INC.

project:
South Salt Lake Public Works Campus

195 West Oakland Ave
South Salt Lake, Utah 84115

title:
ENLARGED SITE PLANS, SECTIONS, ELEVATIONS

sheet:
A012

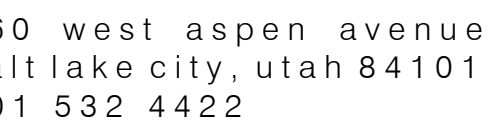

DESIGNS SHOWN AND DESCRIBED HEREIN INCLUDING TECHNICAL DRAWINGS, GRAPHIC REPRESENTATIONS & MODELS THEREOF, ARE PROPRIETARY & CAN NOT BE REPRODUCED, COPIED, Duplicated, OR COMMERCIALY EXPLOITED IN WHOLE OR IN PART WITHOUT THE SOLE AND EXPRESS WRITTEN PERMISSION FROM METHOD STUDIO INC.

Project: Youth Salt Lake Public Works Campus

5 West Oakland Ave
South Salt Lake, Utah 84115

le:
WATER TOWER
LAN

SCALE: $1/8" = 1'-0"$

Sheet:


S701

FOOTING SCHEDULE										
MARK	WIDTH	LENGTH	DEPTH	REINFORCING CROSS-WIDE			REINFORCING LENGTH-WISE			
				NO.	SIZE	LENGTH	NO.	SIZE	LENGTH	SPACING
CF24	34"	CONT.	12"	-	-	-	(3)	#4	CONT.	EQUAL
CF30	20"	CONT.	12"	-	-	-	(3)	#4	CONT.	EQUAL
CF36	36"	CONT.	12"	-	#4	2-6"	12' O.C.	(4)	#4	CONT.
CF36T	36"	CONT.	14"	-	#4	2-6"	12' O.C.	(4)	#4	CONT.
CF38T	38"	CONT.	14"	-	#4	2-8"	18" O.C.	(5)	#4	CONT.
CF42	42"	CONT.	12"	-	#5	3-0"	14" O.C.	(5)	#4	CONT.
CF54	54"	CONT.	12"	-	#5	4-0"	14" O.C.	(4)	#5	CONT.
CF54	60"	CONT.	12"	-	#5	4-6"	12" O.C.	(5)	#5	CONT.
CF58	66"	CONT.	14"	-	#5	5-0"	12" O.C.	(5)	#5	CONT.
CF78	78"	CONT.	14"	-	#5	6-0"	12" O.C.	(7)	#5	CONT.
CF94	84"	CONT.	14"	-	#5	6-6"	14" O.C.	(8)	#5	CONT.
CF108	90"	CONT.	16"	-	#5	7-0"	10" O.C.	(9)	#5	CONT.
CF120T	108"	CONT.	12"	-	#6	8-6"	8" O.C.	(8)	#5	CONT.
CF120T	120"	CONT.	20"	-	#6	9-6"	8" O.C.	(13)	#6	CONT.
F3	3'-0"	3'-0"	12"	(4)	#4	2-6"	EQUAL	(4)	#4	2-6"
F4	4'-0"	4'-0"	12"	(6)	#4	3-6"	EQUAL	(6)	#4	3-6"
*F4T	5'-0"	4'-0"	26"	(5)	#4	3-6"	EQUAL	(5)	#4	3-6"
F5	5'-0"	5'-0"	12"	(7)	#4	4-6"	EQUAL	(7)	#4	4-6"
F6	6'-0"	6'-0"	12"	(7)	#5	5-6"	EQUAL	(7)	#5	5-6"
*F6	6'-0"	6'-0"	12"	(7)	#5	5-6"	EQUAL	(7)	#5	5-6"
F7	7'-0"	7'-0"	14"	(8)	#5	6-6"	EQUAL	(8)	#5	6-6"
*F7	7'-0"	7'-0"	16"	(8)	#5	6-6"	EQUAL	(8)	#5	6-6"
*F7T	7'-0"	7'-0"	24"	(9)	#6	6-6"	EQUAL	(9)	#6	6-6"
F8	8'-0"	8'-0"	16"	(8)	#6	7-6"	EQUAL	(8)	#6	7-6"
F9	9'-0"	9'-0"	26"	(10)	#6	8-6"	EQUAL	(10)	#6	8-6"
*F9T	9'-0"	9'-0"	18"	(10)	#6	8-6"	EQUAL	(10)	#6	8-6"
F9+12	9'-0"	12'-0"	18"	(10)	#6	8-6"	EQUAL	(11)	#6	12-6"
F10	10'-0"	10'-0"	20"	(13)	#6	9-6"	EQUAL	(13)	#6	9-6"
F11	11'-0"	11'-0"	22"	(11)	#7	10-6"	EQUAL	(11)	#7	10-6"
*F11+14	14'-0"	14'-0"	26"	(17)	#7	13-6"	EQUAL	(17)	#7	13-6"
*F15	15'-0"	15'-0"	28"	(19)	#7	14-6"	EQUAL	(19)	#7	14-6"
*F16	16'-0"	16'-0"	28"	(20)	#7	15-6"	EQUAL	(20)	#7	15-6"


* THESE FOOTINGS ARE TO GET (2) MATS OF STEEL. (1) TOP & (1) BOTTOM AS SHOWN IN SCHEDULE
SUGGESTED FOOTING STEP



2 WATER TOWER ELEVATION

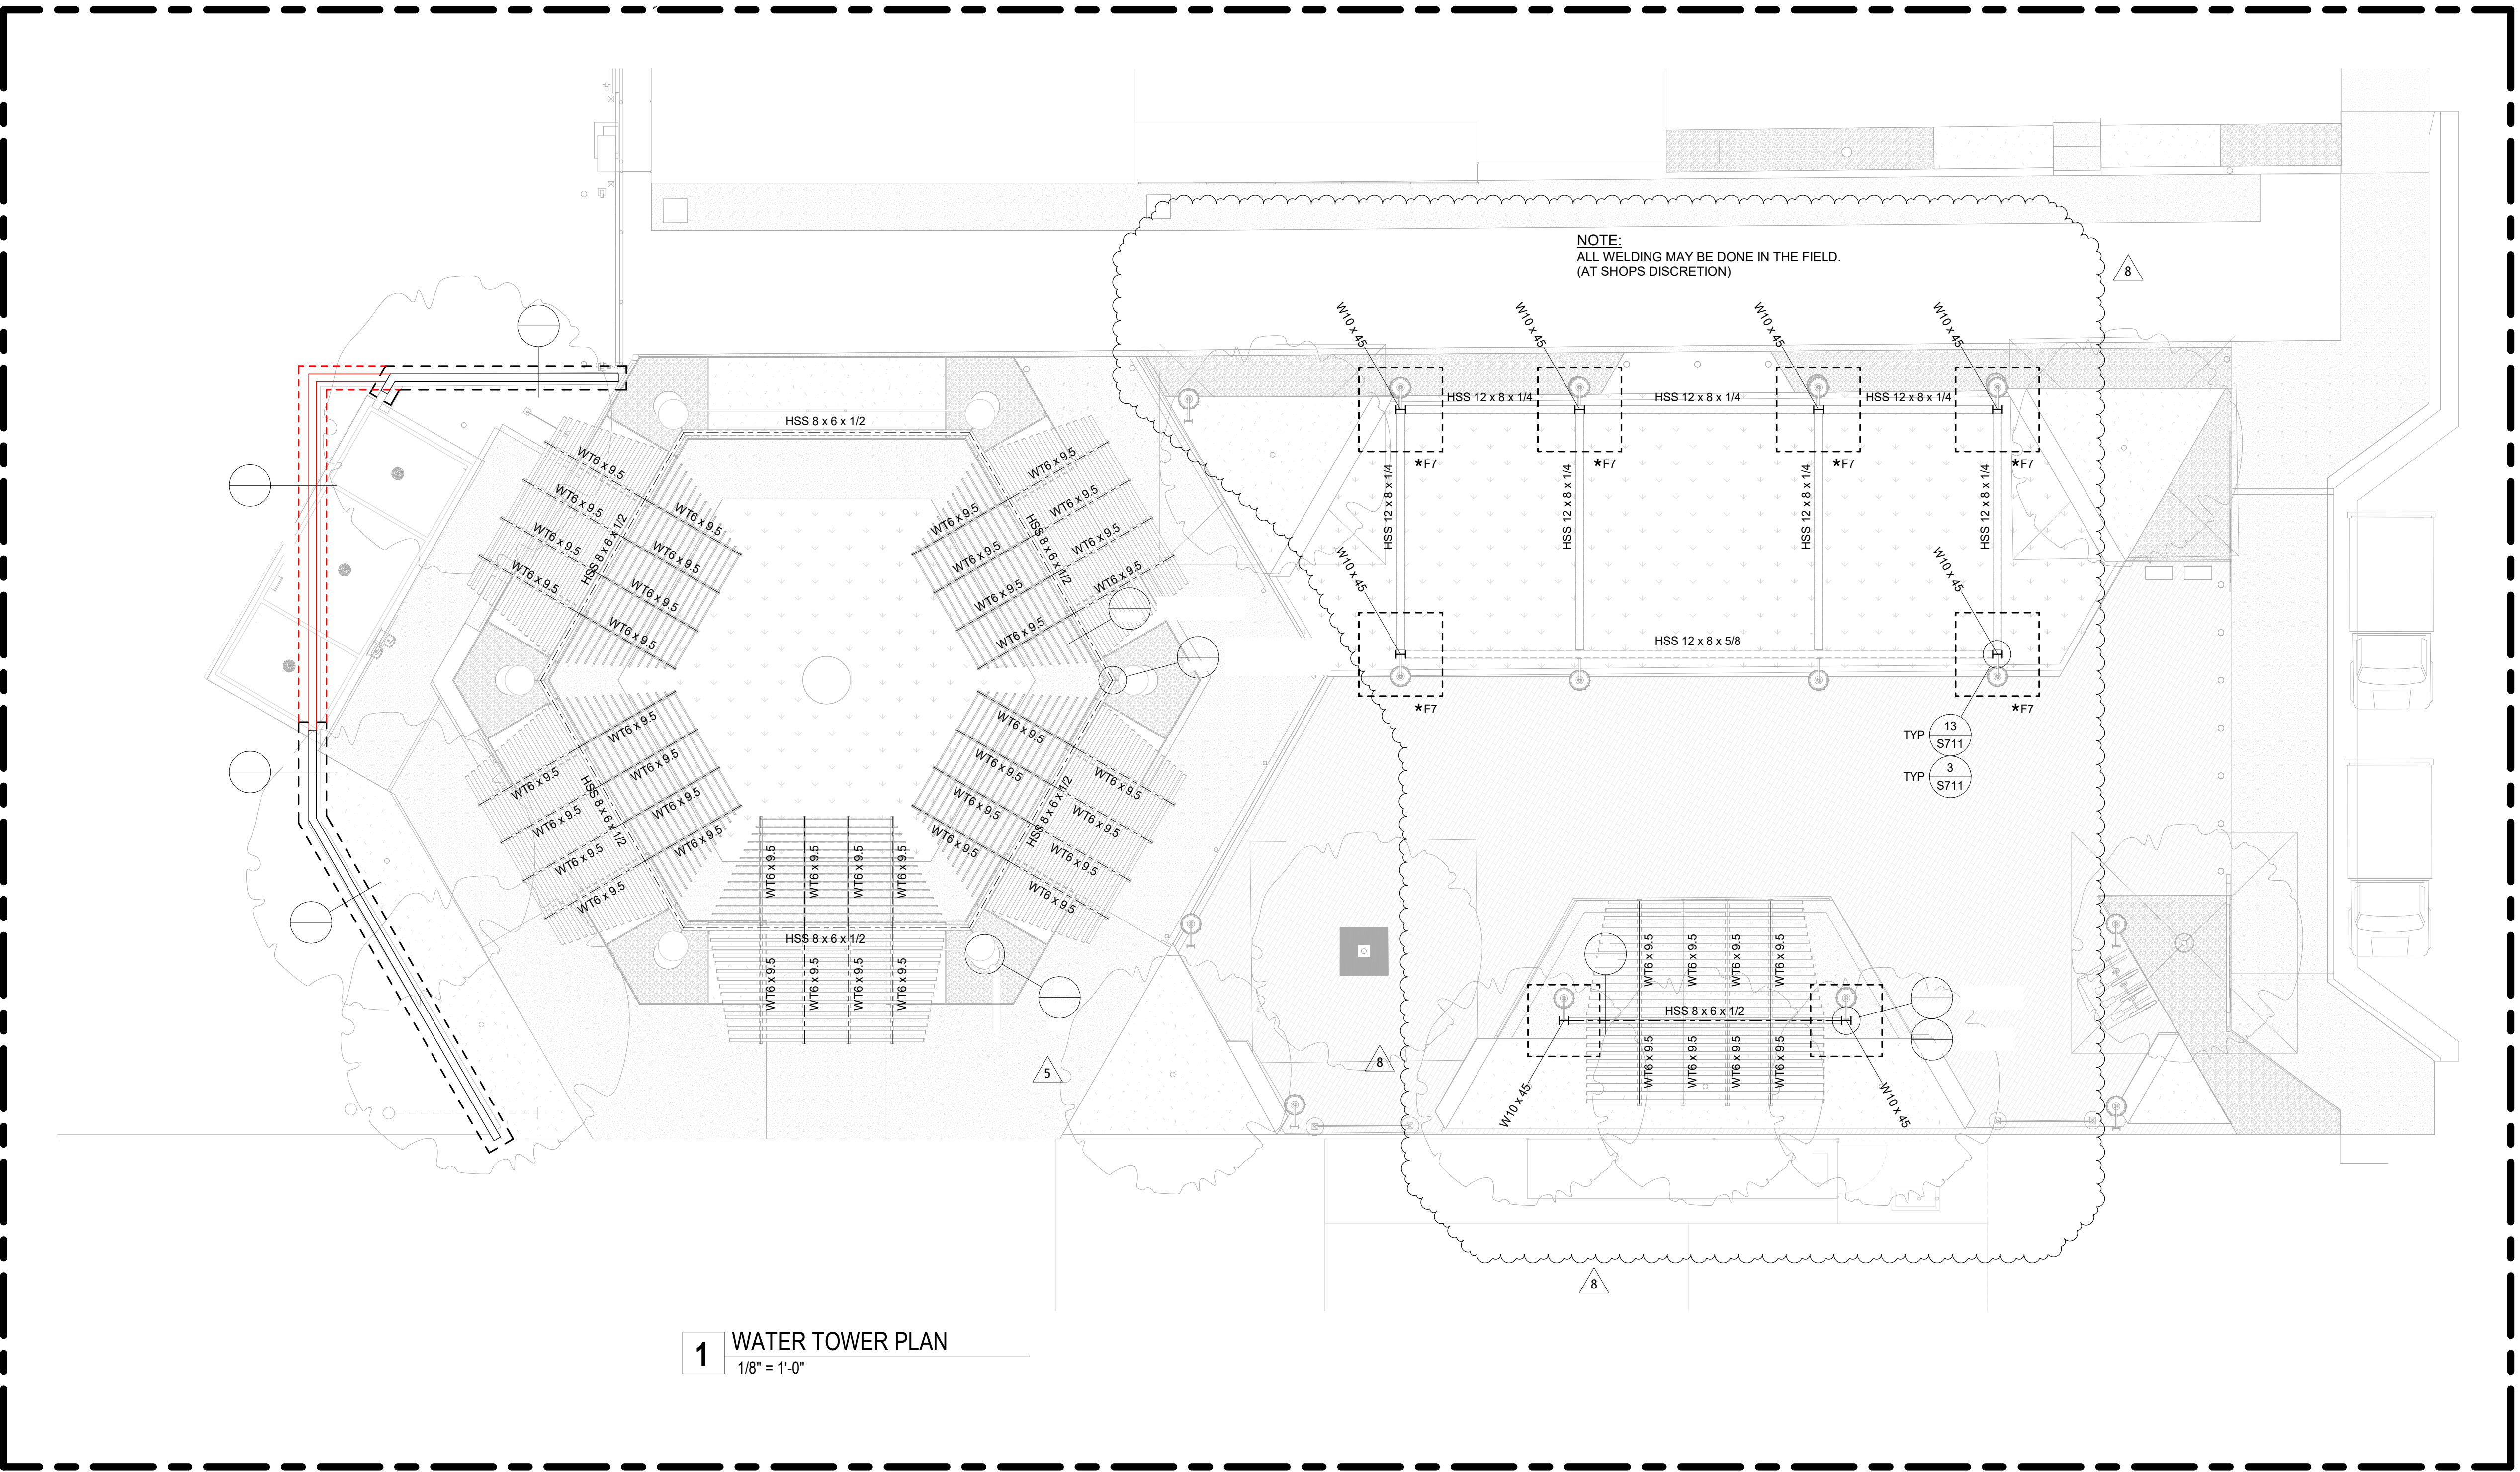

1 WATER TOWER PLAN

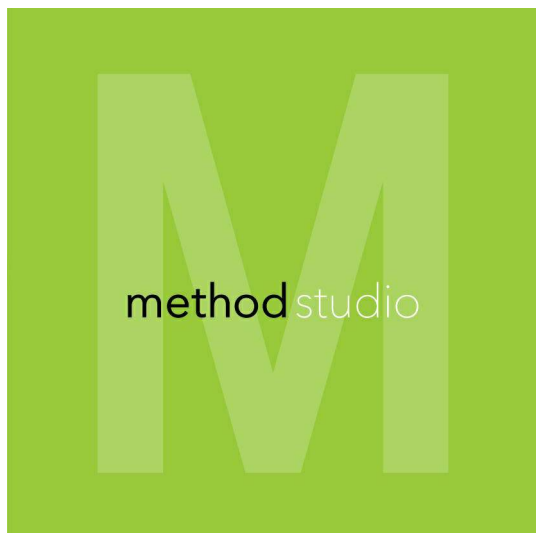

360 west aspen avenue
salt lake city, utah 84101
801 532 4422

UNLESS A PROFESSIONAL SEAL WITH SIGNATURE AND
DATE IS AFFIXED, THIS DOCUMENT IS PRELIMINARY AND IS
NOT INTENDED FOR CONSTRUCTION, RECORDING,
PURPOSES, OR IMPLEMENTATION

THE DESIGN SHOWN AND DESCRIBED HEREIN INCLUDING
ALL TECHNICAL DRAWINGS, GRAPHIC REPRESENTATIONS &
MODELS THEREOF, ARE PROPRIETARY & CAN NOT BE
COPIED, DULICATED, OR COMMERCIALLY EXPLOITED IN
WHOLE OR IN PART WITHOUT THE SOLE AND EXPRESS
WRITTEN PERMISSION FROM METHOD STUDIO, INC.

project:
**South Salt
Lake Public
Works
Campus**


195 West Oakland Ave
South Salt Lake, Utah 84115


title:
**CONSTRUCTION
DETAILS**

SCALE: AS SHOWN


sheet:

S711

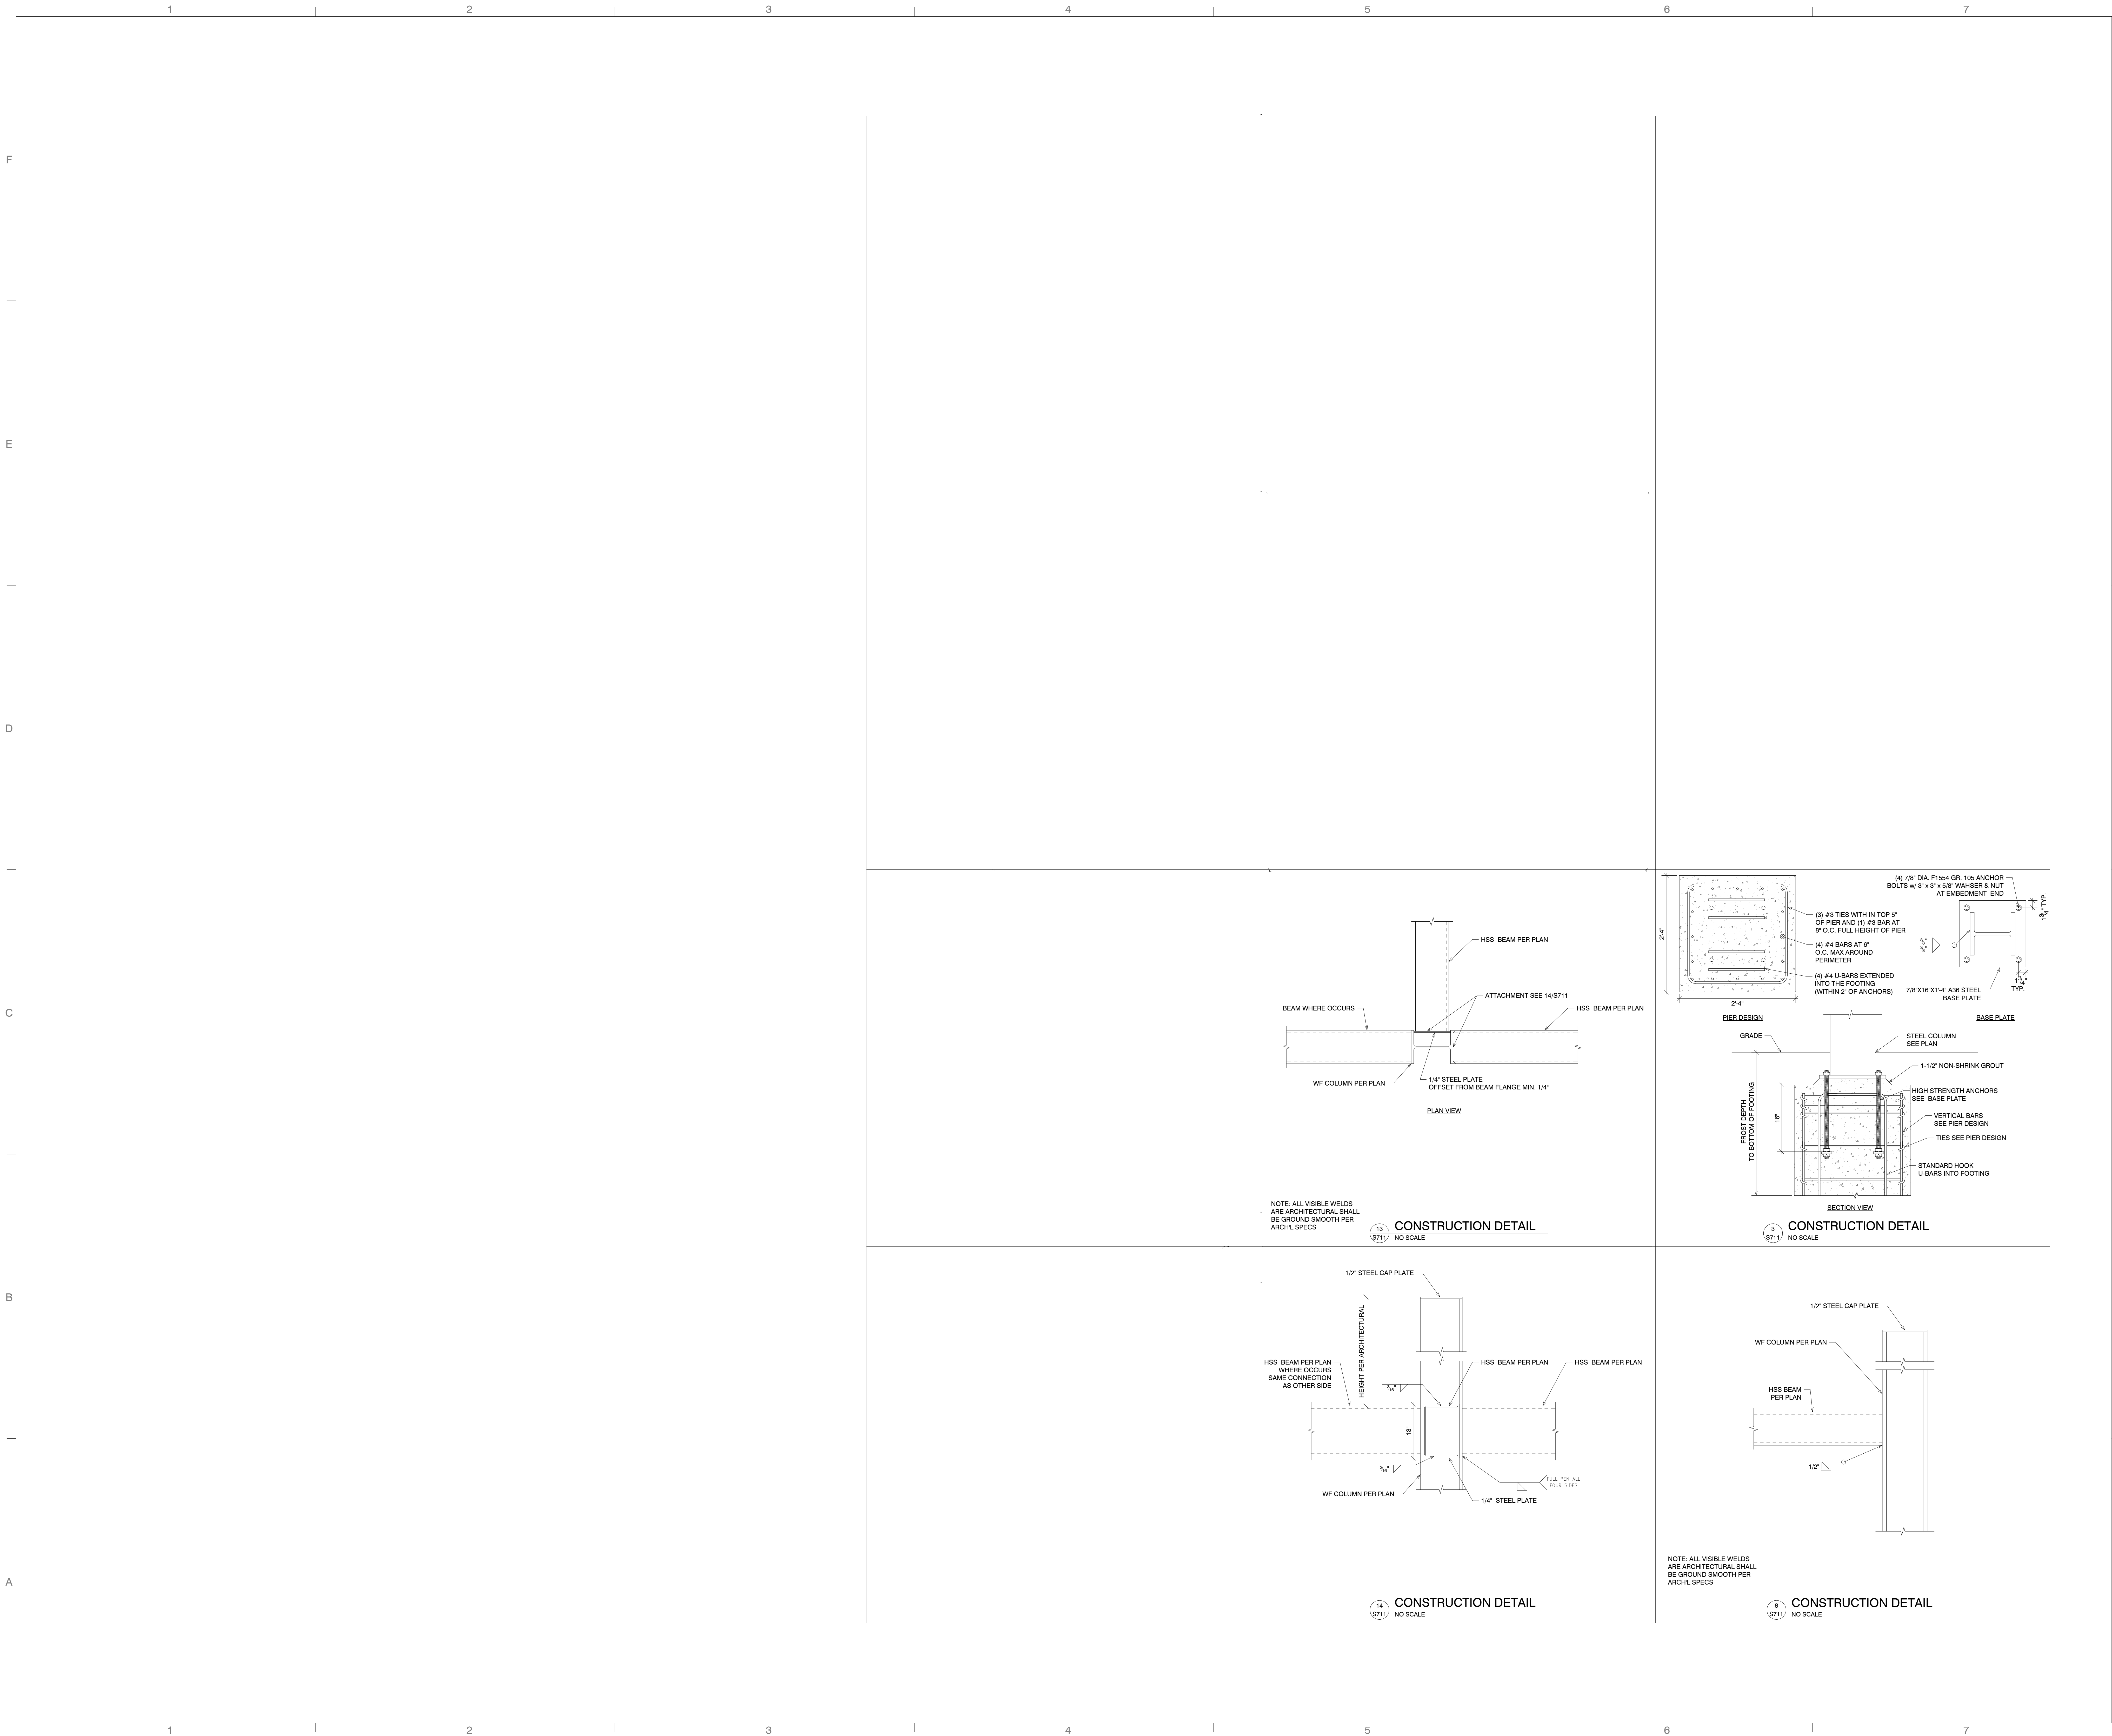


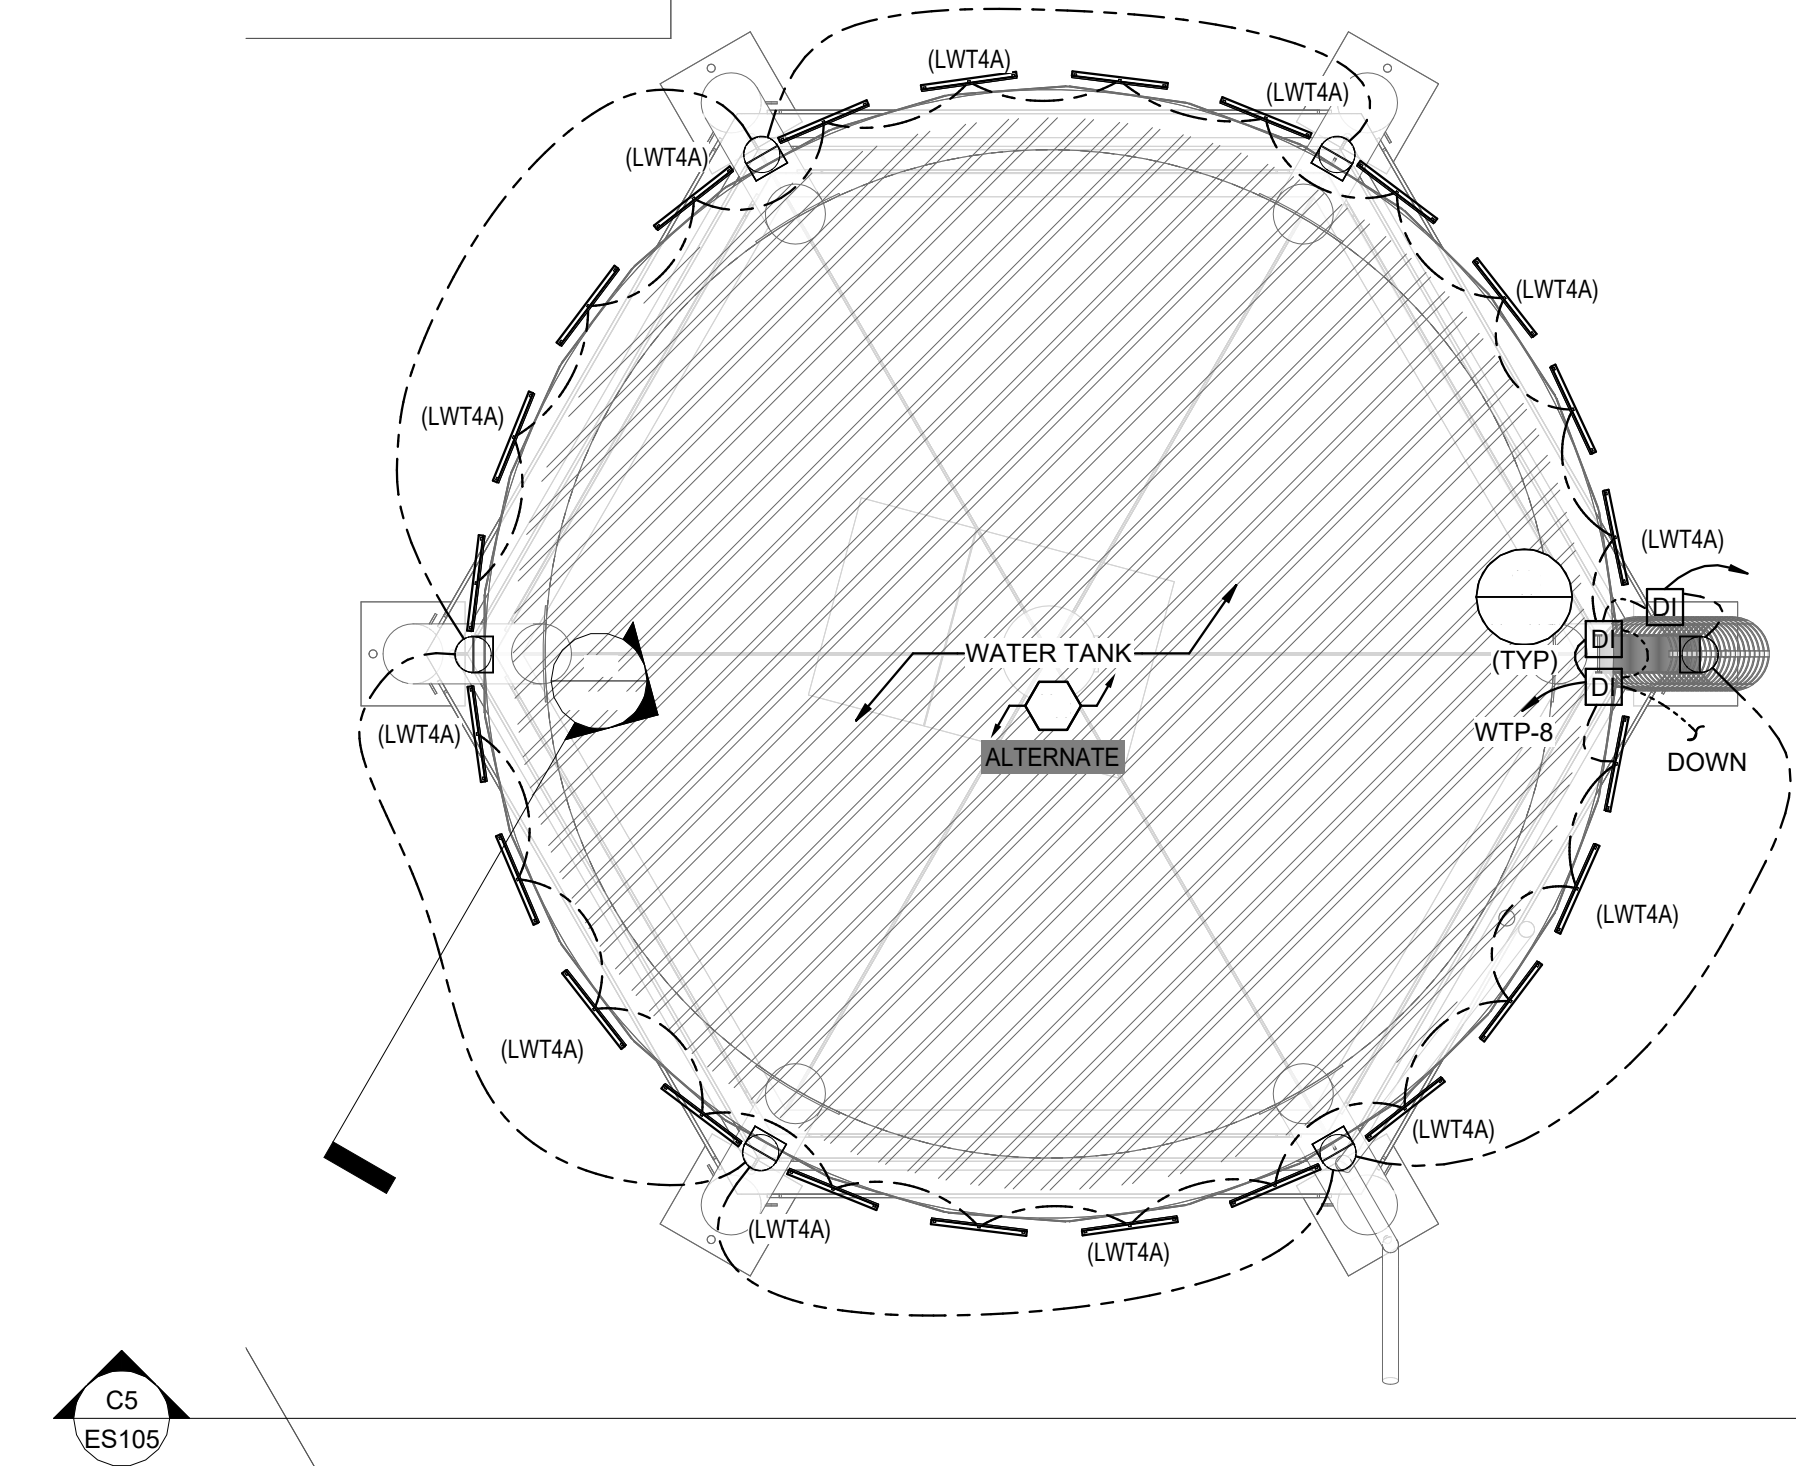

E3 ENLARGED WATER TOWER CATWALK
SCALE: 1/8" = 1'-0"

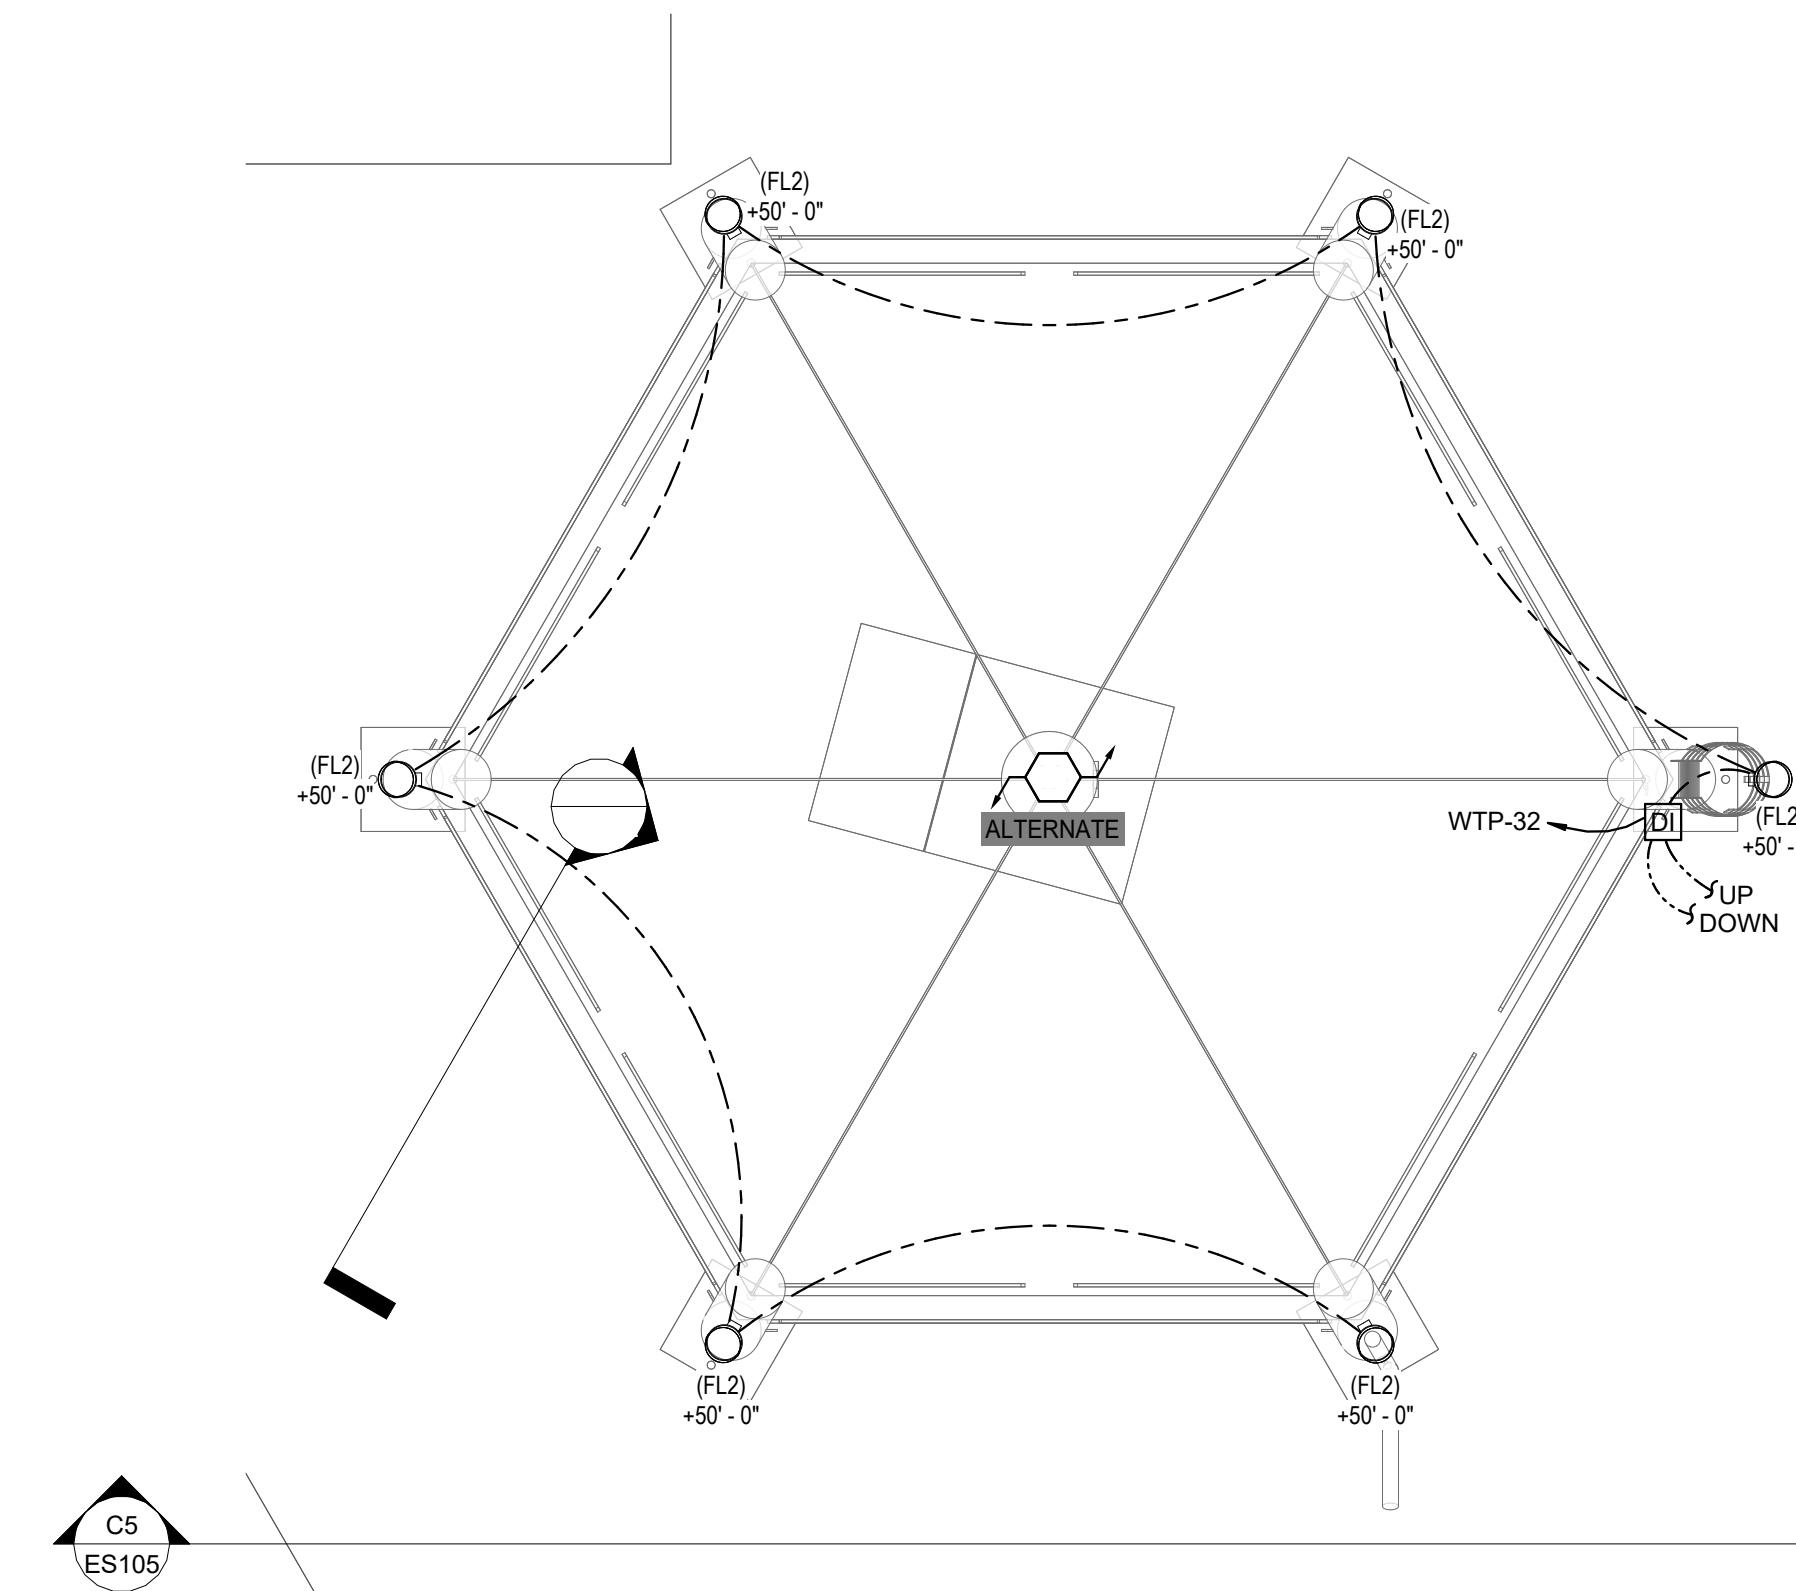

C3 ENLARGED WATER TOWER MID. LIGHTING
SCALE: 1/8" = 1'-0"

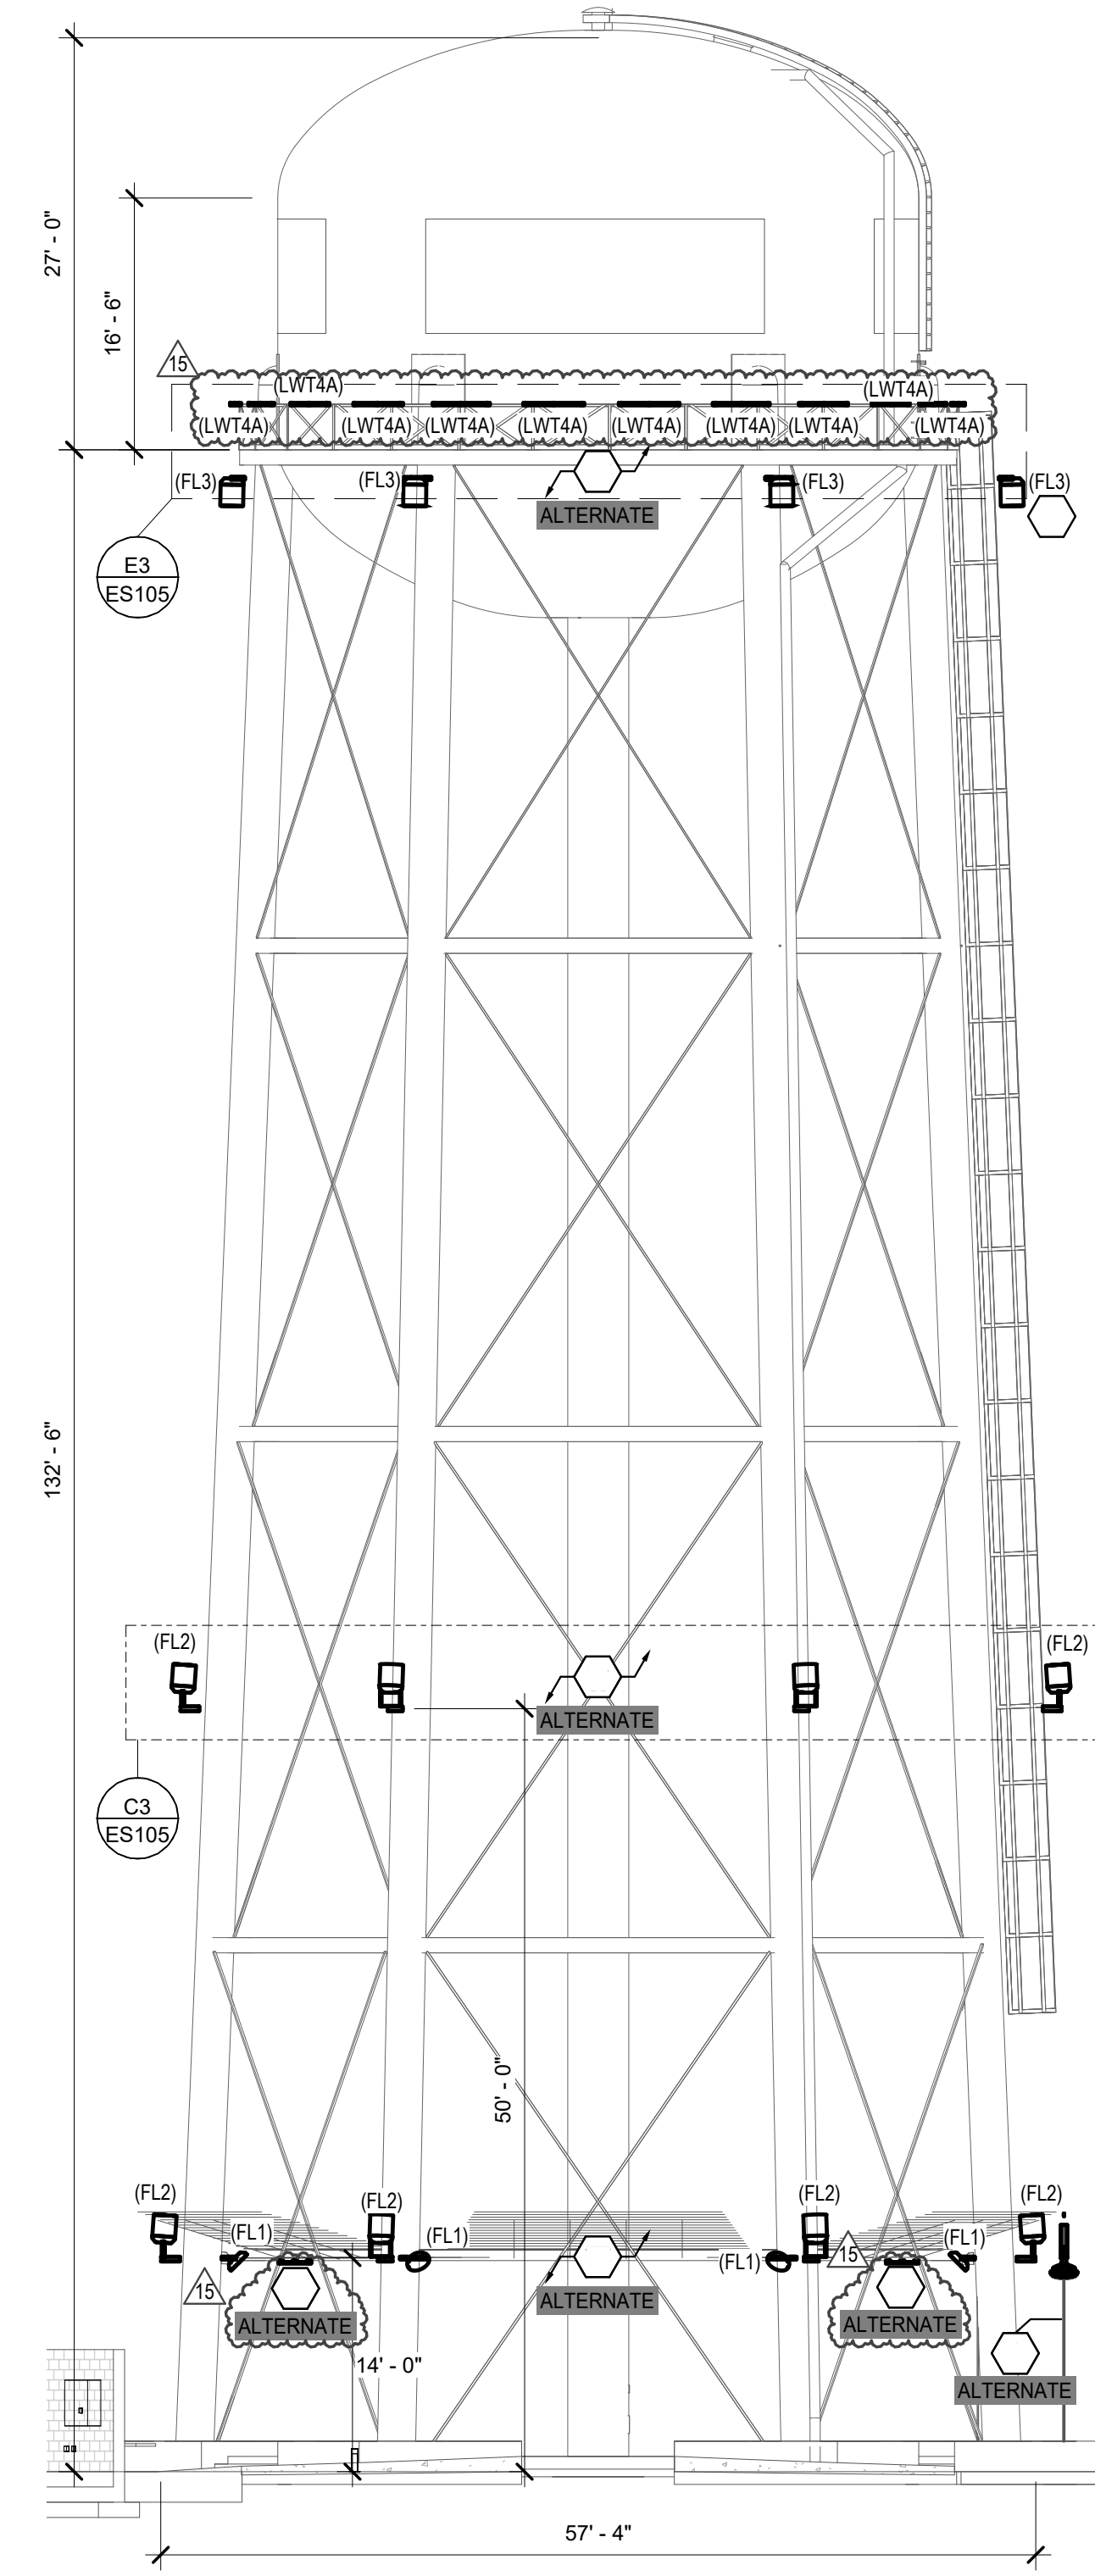

C5 WATER TOWER SECTION VIEW
SCALE: 3/32" = 1'-0"

SHEET KEYNOTES

- 1 PLATFORM SHALL BE RECONFIGURED TO MEET THE NEEDS OF THE SUBMITTED GENERATOR.
- 2 LOCATE EQUIPMENT IN LIGHTING CONTROLLER CABINET.
- 3 MOUNT ON LADDER CAGE.
- 4 DATA INJECTOR FOR FESTOON LIGHTING. LOCATE IN DMX ENCLOSURE. INTEGRATE WITH WATER TOWER DMX HEADEND. PROVIDE ALL REQUIRED COMPONENTS FOR A COMPLETE AND FUNCTIONING SYSTEM.
- 5 SUBMITTED GENERATOR WITH REQUIRED CLEARANCES AND PLATFORM SHALL NOT BE LARGER THAN THE COMBINED GENERATOR/ENCLOSURE DIMENSIONS SHOWN.
- 6 INTEGRAL PANELBOARD TO GENERATOR WITH REQUIRED AUXILIARY GENERATOR LOADS.
- 7 ROUTE ALL CONDUITS FOR WATER TOWER ALONG THIS WATER TOWER LEG.
- 8 NEW POWER PROVIDED BY UTILITY.
- 9 ASSOCIATED EPO FOR GENERATOR, SEE ONE-LINE DIAGRAM.
- 10 PROVIDE AS PART OF ADD ALTERNATE #1.
- 11 PROVIDE AS PART OF ADD ALTERNATE #2.
- 12 CMU WALL DEPENDANT ON ADD ALTERNATE #3; IF ADD ALTERNATE #3 IS NOT ACCEPTED, PROVIDE STRUCTURE TO MOUNT EQUIPMENT ON.
- 13 CIRCUIT SHOWN ON OVERALL PLAN.
- 14 PROVIDE POWER FOR SIGNAGE LIGHTING. COORDINATE WITH ARCHITECT FOR LOCATION.
- 15 CONTRACTOR TO PROVIDE UNISTRUT FOR MOUNTING PV DISCONNECTS.
- 16 ASSOCIATED EPO FOR BESS, SEE ONE-LINE DIAGRAM.
- 17 COORDINATE POWER WITH LIT SIGNAGE. POWER IS INTENDED TO STUB UP INTO SIGNAGE.
- 18 PROVIDE KNOX REMOTE POWER BOX. SEE SINGLE LINE DIAGRAM.
- 19 ALL CONDUITS ON THIS STRUCTURE SHALL BE WHITE, SOLID WALL, HOPE AND SHALL UTILIZE STAINLESS STEEL JUNCTION BOXES DUE TO THE CORROSIVE SALT.
- 20 PROVIDE CONDUIT AND WIRING PER MANUFACTURER RECOMMENDATIONS BETWEEN CONTROLLER AND UNIT MINIMUM ALONG WITH CORROSIVE RESISTANT REQUIREMENTS LISTED IN THE SPACE.
- 21 ALL DEVICES SHALL BE CORROSIVE RESISTANT, STAINLESS STEEL OR HAVE SEAL-ABLE COVERS.


THE DESIGN SHOWN AND DESCRIBED HEREIN INCLUDING
ALL TECHNICAL DRAWINGS, GRAPHIC REPRESENTATIONS &
MODELS THEREOF, ARE PROPRIETARY & CAN NOT BE
COPIED, DULICATED, OR COMMERCIALLY EXPLOITED IN
WHOLE OR IN PART WITHOUT THE SOLE AND EXPRESS
WRITTEN PERMISSION FROM METHOD STUDIO, INC.

project:
**South Salt
Lake Public
Works
Campus**

195 West Oakland Ave
South Salt Lake, Utah 84115

title:
**ELECTRICAL
SITE PLAN
ENLARGED**

sheet:
ES105

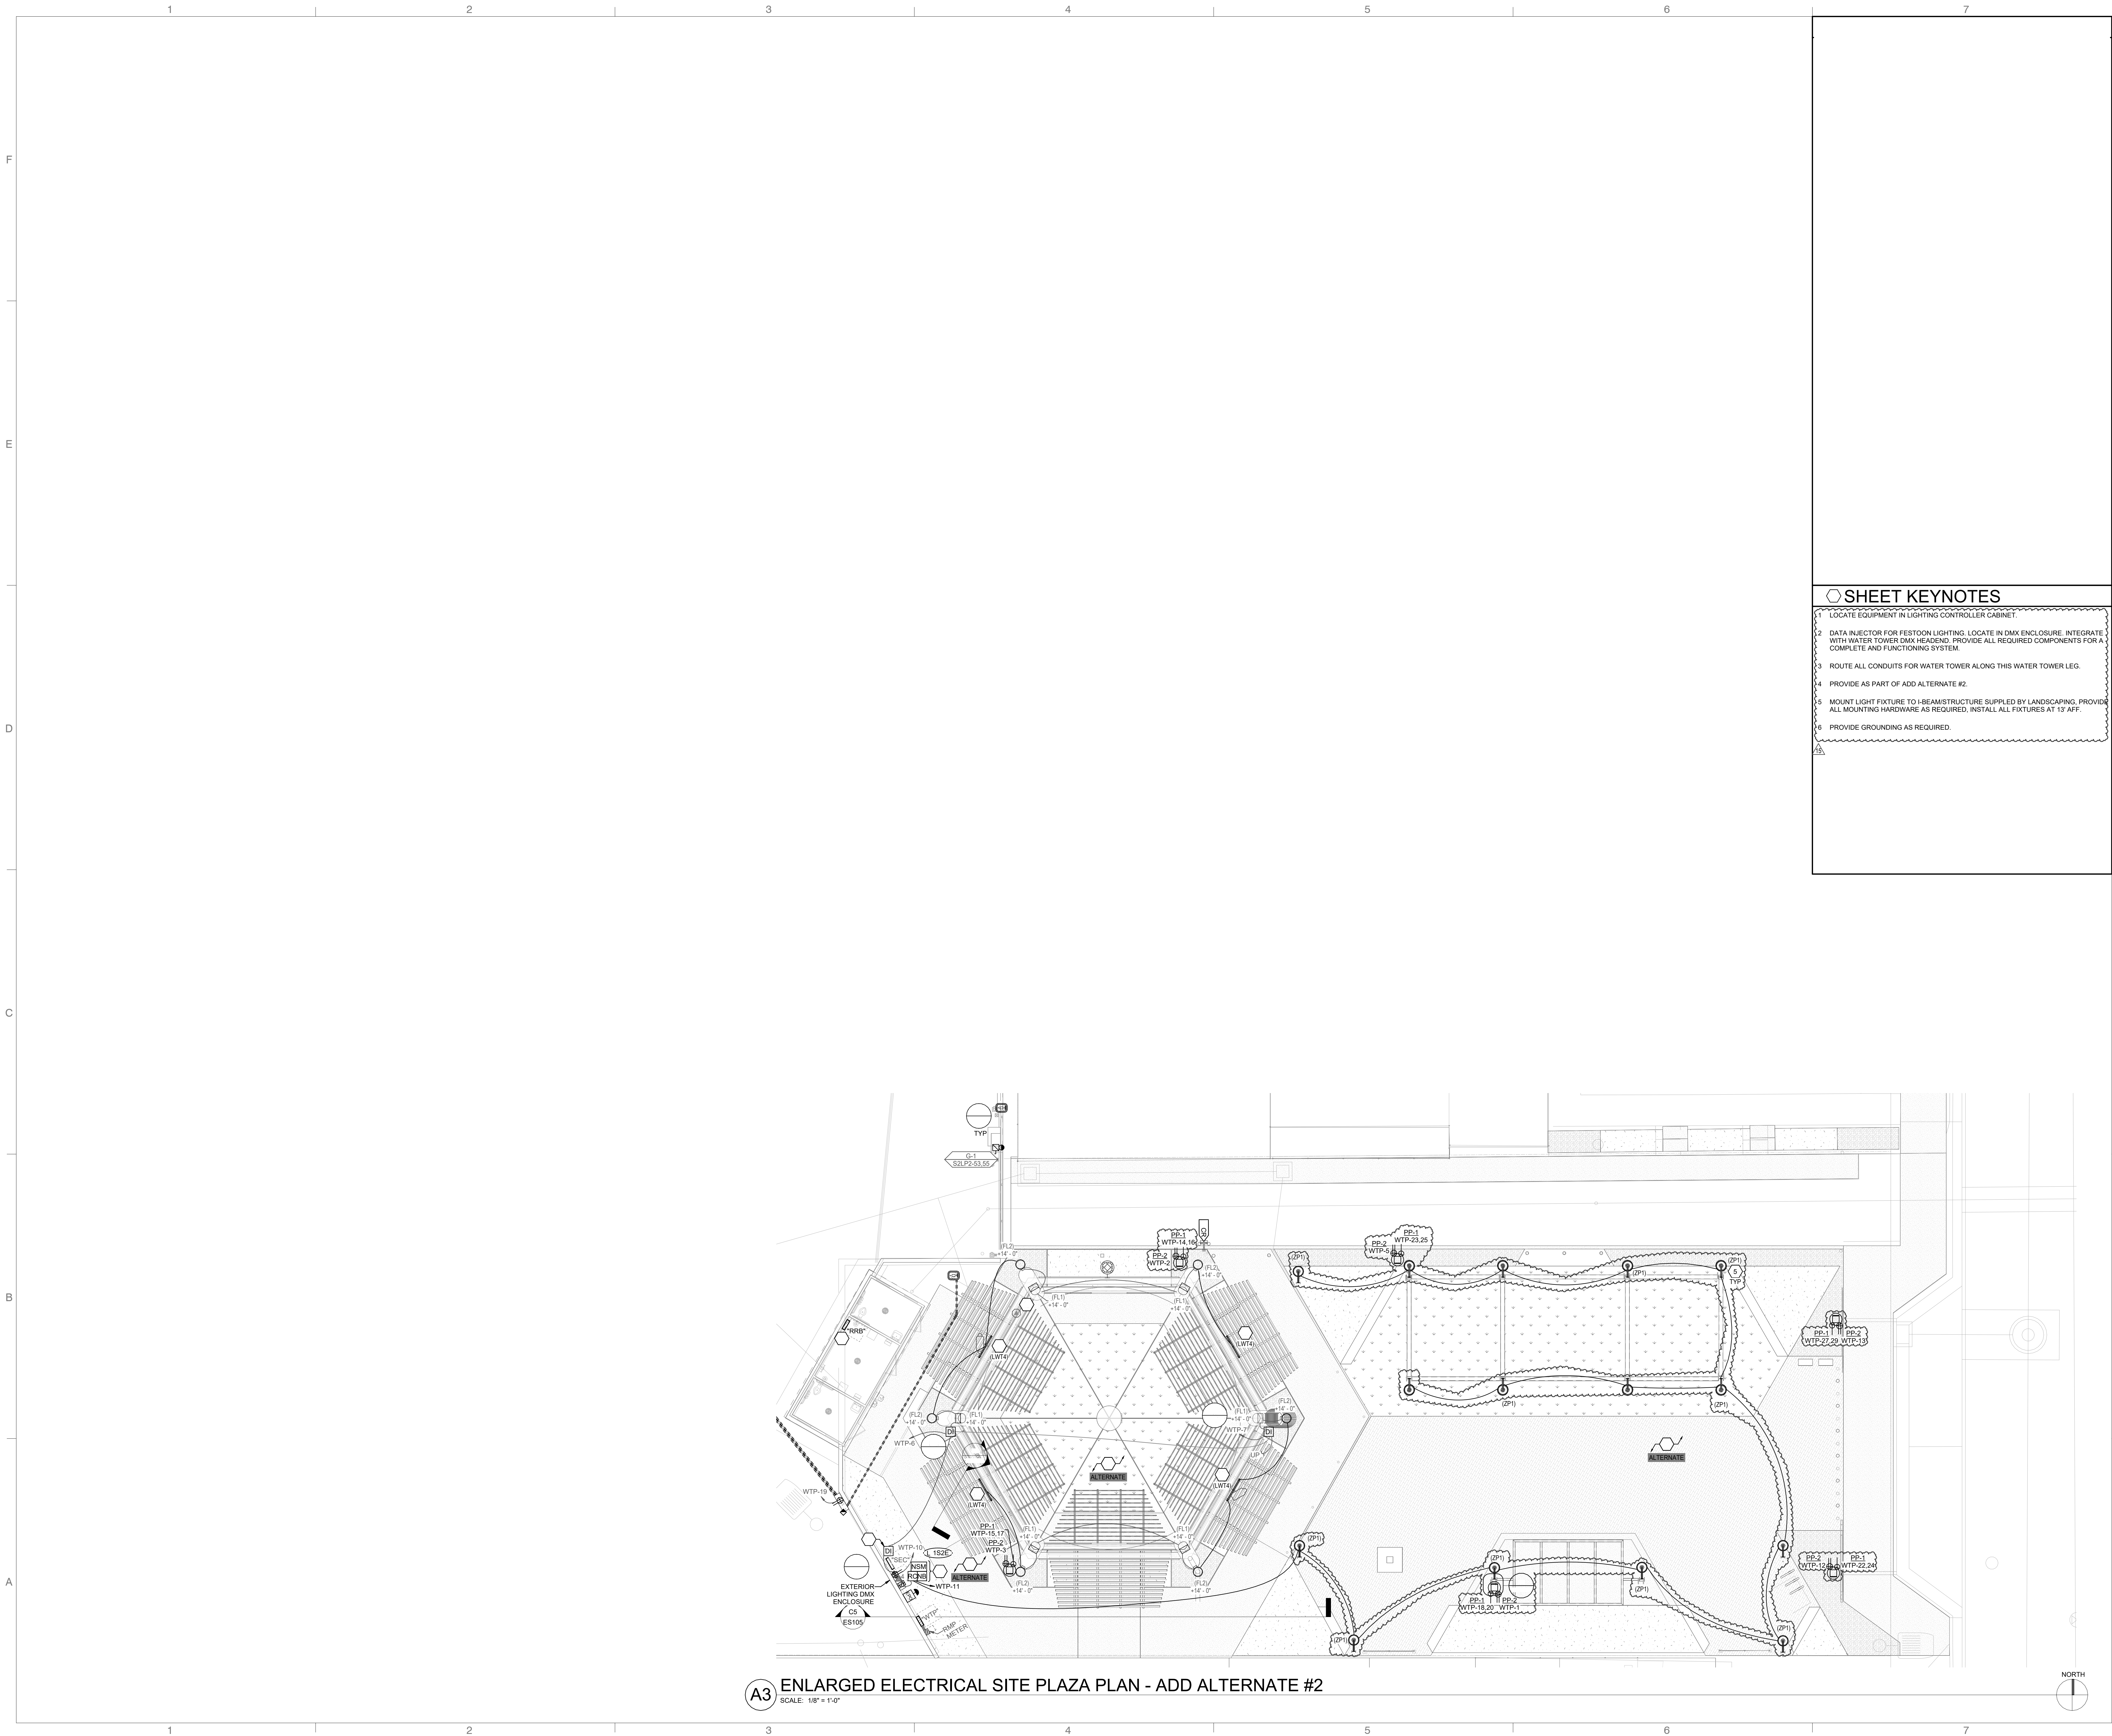

360 west aspen avenue
salt lake city, utah 84101
801 532 4422

UNLESS A PROFESSIONAL SEAL WITH SIGNATURE AND
DATE IS AFFIXED, THIS DOCUMENT IS PRELIMINARY AND IS
NOT INTENDED FOR CONSTRUCTION, RECORDING,
PURPOSES, OR IMPLEMENTATION

SHEET KEYNOTES

- 1 LOCATE EQUIPMENT IN LIGHTING CONTROLLER CABINET.
- 2 DATA INJECTOR FOR FESTOON LIGHTING. LOCATE IN DMX ENCLOSURE. INTEGRATE WITH WATER TOWER DMX HEADEND. PROVIDE ALL REQUIRED COMPONENTS FOR A COMPLETE AND FUNCTIONING SYSTEM.
- 3 ROUTE ALL CONDUITS FOR WATER TOWER ALONG THIS WATER TOWER LEG.
- 4 PROVIDE AS PART OF ADD ALTERNATE #2.
- 5 MOUNT LIGHT FIXTURE TO I-BEAM STRUCTURE SUPPLIED BY LANDSCAPING. PROVIDE ALL MOUNTING HARDWARE AS REQUIRED. INSTALL ALL FIXTURES AT 13' AFF.
- 6 PROVIDE GROUNDING AS REQUIRED.

THE DESIGN SHOWN AND DESCRIBED HEREIN INCLUDING
ALL TECHNICAL DRAWINGS, GRAPHIC REPRESENTATIONS &
MODELS THEREOF, ARE PROPRIETARY & CAN NOT BE
COPIED, DULICATED, OR COMMERCIALLY EXPLOITED IN
WHOLE OR IN PART WITHOUT THE SOLE AND EXPRESS
WRITTEN PERMISSION FROM METHOD STUDIO INC.

project:

**South Salt
Lake Public
Works
Campus**

195 West Oakland Ave
South Salt Lake, Utah 84115

title:

**ELECTRICAL
SITE PLAN
ENLARGED**

sheet:

ES106

6/20/2025 12:10:37 PM Autodesk Docs\\South Salt Lake City Public Works Campus\\240183 - EDC Central.rvt



360 west aspen avenue
salt lake city, utah 84101
801 532 4422

UNLESS A PROFESSIONAL SEAL WITH SIGNATURE AND DATE IS AFFIXED, THIS DOCUMENT IS PRELIMINARY AND IS NOT INTENDED FOR CONSTRUCTION, RECORDING, PURPOSES, OR IMPLEMENTATION

THE DESIGN SHOWN AND DESCRIBED HEREIN INCLUDING ALL TECHNICAL DRAWINGS, GRAPHIC REPRESENTATIONS, A MODEL THEREOF, ARE PROPRIETARY & CAN NOT BE COPIED, DULICATED, OR COMMERCIALLY EXPLOITED IN WHOLE OR IN PART WITHOUT THE SOLE AND EXPRESS WRITTEN PERMISSION FROM METHOD STUDIO, INC.

project:

South Salt
Lake Public
Works
Campus

195 West Oakland Ave
South Salt Lake, Utah 84115

title:

EXTERIOR
LIGHTING
FIXTURE
SCHEDULES

sheet:

EL602

EXTERIOR LIGHTING FIXTURE SCHEDULE

GENERAL NOTES

- SUBSTITUTIONS AND/OR EQUAL FIXTURES MUST RECEIVE APPROVAL PRIOR TO BIDDING. THEY MUST BE SUBMITTED TO THE ENGINEER NO LESS THAN 2 WEEKS PRIOR TO BID OPENING.
- SAMPLES MUST BE PROVIDED FOR ANY AND ALL FIXTURES UPON A/E REQUEST PRIOR TO RELEASING FIXTURES.
- ALL FIXTURES SHALL BE LISTED AND APPROVED FOR THEIR INTENDED USE AND LOCATION.
- VERIFY THE PROPER MOUNTING KITS OR ACCESSORIES TO FACILITATE INSTALLATION AS SHOWN AT EACH LOCATION ON THE DRAWINGS.
- COMPLY WITH THE "INTERIOR LIGHTING" SECTION OF THE SPECIFICATIONS.
- ALL LIGHT FIXTURES TO BE EITHER "DLC" OR "LIGHTING FACTS" LISTED OR TO BE APPROVED BY ARCHITECT/ENGINEER AND OWNER.
- CONTRACTOR ALLOWANCE PRICES ARE ACCURATE WHEN THIS JOB WAS SPECIFIED. CONTRACTOR AND ELECTRICAL DISTRIBUTOR SHALL VERIFY THIS ALLOWANCE AND REPORT ANY PROBLEMS TO THE ENGINEER BEFORE THE BID. ALLOWANCE PRICE MAY OR MAY NOT INCLUDE LAMP(S) OR FREIGHT AS NOTED, AND DO NOT INCLUDE ANY TAXES.

ID	DESCRIPTION	SIZE (NOMINAL)	LUMINAIRE				DRIVER				MANUFACTURER	
			BUG RATING	BACK UP	GLARE	LUMENS	COLOR TEMP	CRI	TYPE	VOLTAGE		WATTS
(B-1)	DESCRIPTION: LED BOLLARD FINISH: SCBA OPTICS: TYPE III	HEIGHT: 36" DIAMETER: 4.5"	-	-	-	986	4000K	-	LED	120/277V	10	LUMINIS (L0613-4LE) BULLRUD BOLLARD (BB-TANS-BL) LIGMAN LIGHTING (LVA-10011-15W-W40-XX-120/277V)
(OCP1)	DESCRIPTION: SURFACE MOUNT CANOPY LIGHT MOUNTING: SURFACE FINISH: SCBA OPTICS: UV RESIST POLYCARBONATE FROSTED OPTICAL LENS OPTIONS: INTEGRAL OCCUPANCY SENSOR WIND RATING: - EM: NONE	LENGTH: 12" WIDTH: 12" DEPTH: 5"	-	-	-	7,000	4000K	-	LED (0-10V DIMMIN G)	120/277V	60	SPITZER (PGCA) ALS (CPR) LUMARK (RPGC2SS)
(OW1)	DESCRIPTION: WALL SCONCE MOUNTING: WALL FINISH: SCBA OPTICS: TYPE III DISTRIBUTION OPTIONS: INTEGRAL OCCUPANCY SENSOR WIND RATING: - EM: NONE	HEIGHT: 7.5" WIDTH: 16.9" DEPTH: 10"	-	-	-	4,200	4000K	-	LED (0-10V DIMMIN G)	120/277V	35	GARDCO (OPF-M) LITHONIA (DSXW1) LUMARK (PRV)
(OW1E)	DESCRIPTION: WALL SCONCE MOUNTING: WALL FINISH: SCBA OPTICS: TYPE III DISTRIBUTION OPTIONS: INTEGRAL OCCUPANCY SENSOR WIND RATING: - EM: NONE	HEIGHT: 7.5" WIDTH: 16.9" DEPTH: 10"	-	-	-	4,200	4000K	-	LED (0-10V DIMMIN G)	120/277V	35	GARDCO (OPF-M) LITHONIA (DSXW1) LUMARK (PRV)
(OW2)	DESCRIPTION: WALL SCONCE MOUNTING: WALL FINISH: SCBA OPTICS: TYPE III DISTRIBUTION OPTIONS: INTEGRAL OCCUPANCY SENSOR WIND RATING: - EM: EMERGENCY BATTERY	HEIGHT: 9" WIDTH: 13" DEPTH: 6"	-	-	-	5,000	4000K	-	LED (0-10V DIMMIN G)	120/277V	30	GARDCO (GBM) LITHONIA (WST) OR PRIOR APPROVED EQUALS
(Z1)	DESCRIPTION: MODERN STYLE, LED POLE LIGHT MOUNTING: POLE FINISH: SCBA OPTICS: FORWARD THROW MEDIUM OPTIONS: INTEGRAL OCCUPANCY SENSOR WIND RATING: 120	LENGTH: 32" WIDTH: 18" DEPTH: 7" POLE HEIGHT: 30' BASE ABOVE GRADE: 3'-4"	-	-	-	30,068	4000K	-	LED (0-10V DIMMIN G)	120/277V	219	GARDCO (OPF-M) LITHONIA (RSXZ, RTS) LUMARK (PRV)
(Z2)	DESCRIPTION: DUAL HEAD MODERN STYLE, LED POLE LIGHT MOUNTING: POLE FINISH: SCBA OPTICS: FORWARD THROW MEDIUM OPTIONS: INTEGRAL OCCUPANCY SENSOR WIND RATING: 120	LENGTH: 32" WIDTH: 18" DEPTH: 7" POLE HEIGHT: 30' BASE ABOVE GRADE: 3'-4"	-	-	-	60,136	4000K	-	LED (0-10V DIMMIN G)	120/277V	438	GARDCO (OPF-M) LITHONIA (RSXZ, RTS) LUMARK (PRV)

WATER TOWER & PLAZA LIGHTING FIXTURE SCHEDULE

GENERAL NOTES

- SUBSTITUTIONS AND/OR EQUAL FIXTURES MUST RECEIVE APPROVAL PRIOR TO BIDDING. THEY MUST BE SUBMITTED TO THE ENGINEER NO LESS THAN 2 WEEKS PRIOR TO BID OPENING.
- SAMPLES MUST BE PROVIDED FOR ANY AND ALL FIXTURES UPON A/E REQUEST PRIOR TO RELEASING FIXTURES.
- ALL FIXTURES SHALL BE LISTED AND APPROVED FOR THEIR INTENDED USE AND LOCATION.
- VERIFY THE PROPER MOUNTING KITS OR ACCESSORIES TO FACILITATE INSTALLATION AS SHOWN AT EACH LOCATION ON THE DRAWINGS.
- COMPLY WITH THE "INTERIOR LIGHTING" SECTION OF THE SPECIFICATIONS.
- ALL LIGHT FIXTURES TO BE EITHER "DLC" OR "LIGHTING FACTS" LISTED OR TO BE APPROVED BY ARCHITECT/ENGINEER AND OWNER.
- CONTRACTOR ALLOWANCE PRICES ARE ACCURATE WHEN THIS JOB WAS SPECIFIED. CONTRACTOR AND ELECTRICAL DISTRIBUTOR SHALL VERIFY THIS ALLOWANCE AND REPORT ANY PROBLEMS TO THE ENGINEER BEFORE THE BID. ALLOWANCE PRICE MAY OR MAY NOT INCLUDE LAMP(S) OR FREIGHT AS NOTED, AND DO NOT INCLUDE ANY TAXES.

ID	DESCRIPTION	SIZE (NOMINAL)	LUMINAIRE				DRIVER				MANUFACTURER	
			BUG RATING	BACK UP	GLARE	LUMENS	COLOR TEMP.	CRI	TYPE	VOLTAGE		WATTS
(FL1)	DESCRIPTION: RGBA FLOOD LIGHT, WET LISTED MOUNTING: SURFACE, ADJUSTABLE, CONTRACTOR TO PROVIDE CUSTOM MOUNTING BRACKET FINISH: SCBA OPTICS: 65 DEG, ADJUSTABLE HEAD ANGLE OPTIONS: CROSS HATCH LOUVRE, 3G BRACKET, PROVIDE ALL REQUIRED DATA INJECTOR, DMX TERMINATIONS. JUMPERS, DMX CABLING AND ACCESSORIES FOR A COMPLETE SYSTEM. REFER TO PLANS FOR ADDITIONAL DETAIL.	HEIGHT: 16" DIAMETER: 15"	-	-	-	4,210	RGBA	-	DMX	120V	84	LUMASCAPE (LS9360-800-4CA-73-WF-G-09-PS)(LS6252) TRAXON (AM331850055-HATCH LOUVER) INSIGHT (PROSPOT)
(FL2)	DESCRIPTION: RGBA FLOOD LIGHT, WET LISTED MOUNTING: SURFACE, ADJUSTABLE, CONTRACTOR TO PROVIDE CUSTOM MOUNTING BRACKET FINISH: SCBA OPTICS: 4.5 DEG, ADJUSTABLE HEAD ANGLE OPTIONS: SNOOT, POLE/WALL ARM W/ 3G BRACKET, PROVIDE ALL REQUIRED DATA INJECTOR, DMX TERMINATIONS. JUMPERS, DMX CABLING AND ACCESSORIES FOR A COMPLETE SYSTEM. REFER TO PLANS FOR ADDITIONAL DETAIL.	HEIGHT: 16" DIAMETER: 15"	-	-	-	8,230	RGBA	-	DMX	120V	161	LUMASCAPE (LS9380-1600-4CA-73-VN-G-09-PS)(LS6257)(LS6256-G) TRAXON (AM331850055-HATCH LOUVER-POLE/WALL MOUNT ARM) INSIGHT (PROSPOT)
(FL3)	DESCRIPTION: RGBA FLOOD LIGHT, WET LISTED MOUNTING: SURFACE, ADJUSTABLE, CONTRACTOR TO PROVIDE CUSTOM MOUNTING BRACKET FINISH: SCBA OPTICS: 4.5 DEG, ADJUSTABLE HEAD ANGLE OPTIONS: SNOOT, 3G BRACKET PROVIDE ALL REQUIRED DATA INJECTOR, DMX TERMINATIONS. JUMPERS, DMX CABLING AND ACCESSORIES FOR A COMPLETE SYSTEM. REFER TO PLANS FOR ADDITIONAL DETAIL.	HEIGHT: 16" DIAMETER: 15"	-	-	-	8,230	RGBA	-	DMX	120V	161	LUMASCAPE (LS9380-1600-4CA-73-VN-G-09-PS)(LS6257) TRAXON (AM348380055-SNOOT) INSIGHT (PROSPOT)
(LWT4)	DESCRIPTION: RGBA LINEAR STRIP, WET LISTED MOUNTING: SURFACE, ADJUSTABLE, CONTRACTOR TO PROVIDE CUSTOM MOUNTING BRACKET FINISH: SCBA OPTICS: 100 DEG OPTIONS: ADJUSTABLE BRACKET PROVIDE ALL REQUIRED DATA INJECTOR, DMX TERMINATIONS. JUMPERS, DMX CABLING AND ACCESSORIES FOR A COMPLETE SYSTEM. REFER TO PLANS FOR ADDITIONAL DETAIL.	LENGTH: 48" WIDTH: 2.5" HEIGHT: 3"	-	-	-	3,370	RGBA	-	DMX	120V	48	LUMASCAPE (LS9030-RGBA-73-FL-4-A-09-PS) INSIGHT (PEX) EMINERE (EMINERE4-RGBA-100)
(LWT4A)	DESCRIPTION: RGBA LINEAR STRIP, WET LISTED MOUNTING: SURFACE, ADJUSTABLE, CONTRACTOR TO PROVIDE CUSTOM MOUNTING BRACKET FINISH: SCBA OPTICS: ASYMMETRIC THROW OPTIONS: ADJUSTABLE BRACKET PROVIDE ALL REQUIRED DATA INJECTOR, DMX TERMINATIONS. JUMPERS, DMX CABLING AND ACCESSORIES FOR A COMPLETE SYSTEM. REFER TO PLANS FOR ADDITIONAL DETAIL.	LENGTH: 48" WIDTH: 2.5" HEIGHT: 3"	-	-	-	3,370	RGBA	-	DMX	120V	48	LUMASCAPE (LS9030-RGBA-73-AL-4-A-09-PS) INSIGHT (PEX) EMINERE (EMINERE4-RGBA-WALL WASHER)
(ZP1)	DESCRIPTION: WALK WAY LIGHT FIXTURE WITH CANTILEVER MOUNT, MOUNTED TO 1 BEAM (BY LANDSCAPE), CATENARY LOOP (WHERE SHOWN ON PLANS), CANTILEVER ARM, DOME LIGHT FIXTURE WITH INTEGRATED LED, REMOTE DRIVER AND CAGE WITH REQUIRED MOUNTING HARDWARE MOUNTING SURFACE: 1 BEAM FINISH: SCBA OPTICS: TYPE V DISTRIBUTION	POLE: WIDTH: 8" DEPTH: 8" HEIGHT: 13' FIXTURE: DIAMETER: 20" HEIGHT: 16.5"	-	-	-	3,000	2700K	-	LED	120/277V	26	FIXTURE: BOCK 1TG (S20-41F-120AR) STRUCTURA (PLAZA-PEN-24-TBD-SQR) SPECTRUM (WS1812GV)

F

F

E

E

D

D

C

C

B

B

A

A